

Dist	COUNTY	ROUTE	POST MILES TOTAL PROJECT	SHEET No.	TOTAL SHEETS
06	Ker	58	28.2/31.5	1	16



STATE OF CALIFORNIA  
**DEPARTMENT OF TRANSPORTATION**  
**PROJECT PLANS FOR CONSTRUCTION ON**  
**STATE HIGHWAY**


**IN KERN COUNTY**  
**IN BUTTONWILLOW**  
**FROM 0.4 MILE EAST OF MAIN DRAIN CANAL BRIDGE**  
**TO 0.2 MILE WEST OF ROUTE 5/58 SEPARATION**

TO BE SUPPLEMENTED BY STANDARD PLANS DATED 2010

INDEX OF PLANS

SHEET No.	DESCRIPTION
1	TITLE AND LOCATION MAP
2	TYPICAL CROSS SECTIONS
3	CONSTRUCTION DETAILS
4	CONSTRUCTION AREA SIGNS
5	SUMMARY OF QUANTITIES
6	MODIFY SIGNAL AND COUNT STATION
7-16	REVISED STANDARD PLANS

THE STANDARD PLAN LIST APPLICABLE TO THIS CONTRACT IS INCLUDED IN THE NOTICE TO BIDDERS AND SPECIAL PROVISIONS BOOK.

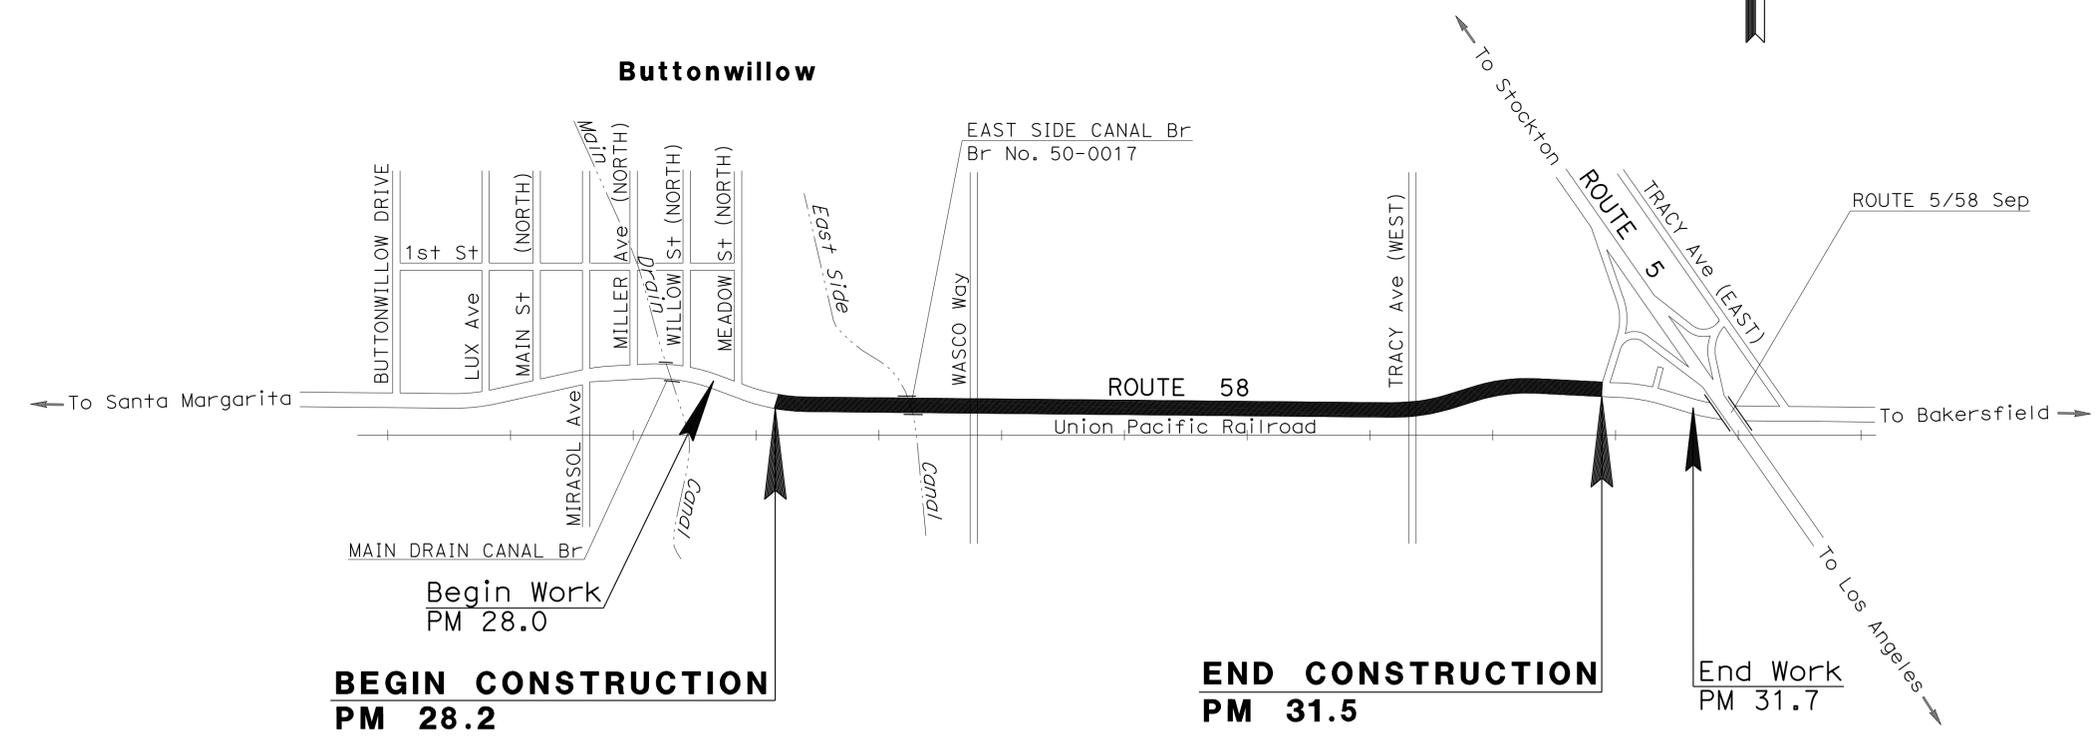

PROJECT MANAGER	TERESA RIX
DESIGN ENGINEER	RENE SANCHEZ

*Zhan Lin* 11-26-14  
PROJECT ENGINEER DATE  
REGISTERED CIVIL ENGINEER

**December 8, 2014**  
PLANS APPROVAL DATE

THE STATE OF CALIFORNIA OR ITS OFFICERS OR AGENTS SHALL NOT BE RESPONSIBLE FOR THE ACCURACY OR COMPLETENESS OF SCANNED COPIES OF THIS PLAN SHEET.



THE CONTRACTOR SHALL POSSESS THE CLASS (OR CLASSES) OF LICENSE AS SPECIFIED IN THE "NOTICE TO BIDDERS."

NO SCALE

CONTRACT No.	<b>06-0T1704</b>
PROJECT ID	<b>0615000030</b>


Dist	COUNTY	ROUTE	POST MILES TOTAL PROJECT	SHEET No.	TOTAL SHEETS
06	Ker	58	28.2/31.5	2	16
<i>Lia Zhi Zhan</i> 11-26-14 REGISTERED CIVIL ENGINEER DATE					
12-8-14			PLANS APPROVAL DATE		
<small>THE STATE OF CALIFORNIA OR ITS OFFICERS OR AGENTS SHALL NOT BE RESPONSIBLE FOR THE ACCURACY OR COMPLETENESS OF SCANNED COPIES OF THIS PLAN SHEET.</small>					

**NOTES:**


- DIMENSIONS OF THE PAVEMENT STRUCTURES (STRUCTURAL SECTION) ARE SUBJECT TO TOLERANCES SPECIFIED IN THE STANDARD SPECIFICATIONS.
- FOR ACCURATE RIGHT OF WAY DATA, CONTACT RIGHT OF WAY ENGINEERING AT THE DISTRICT OFFICE.
- 1' SHOULDER BACKING FROM PM 28.5/28.8, PM 29.2/29.8, PM 20.5/30.8 (WESTBOUND), AND PM 30.7/31.6 (EASTBOUND AND WESTBOUND).

**PAVEMENT CLIMATE REGION:**

INLAND VALLEY

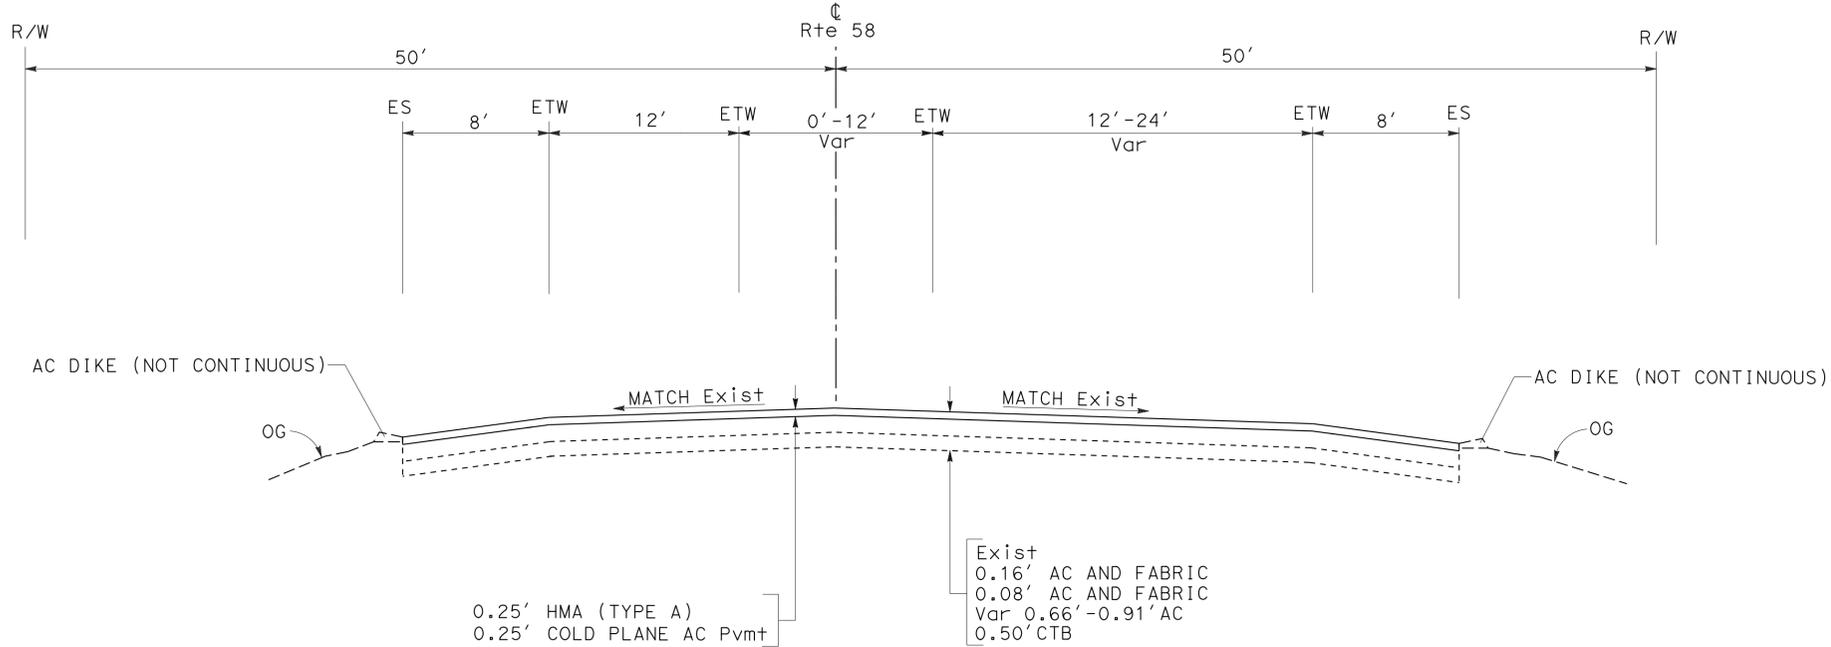

WESTBOUND **ROUTE 58** EASTBOUND  
 PM 28.402 TO PM 28.412  
 (EAST SIDE CANAL BRIDGE NUMBER 500017)  
 PM 31.415 TO PM 31.450

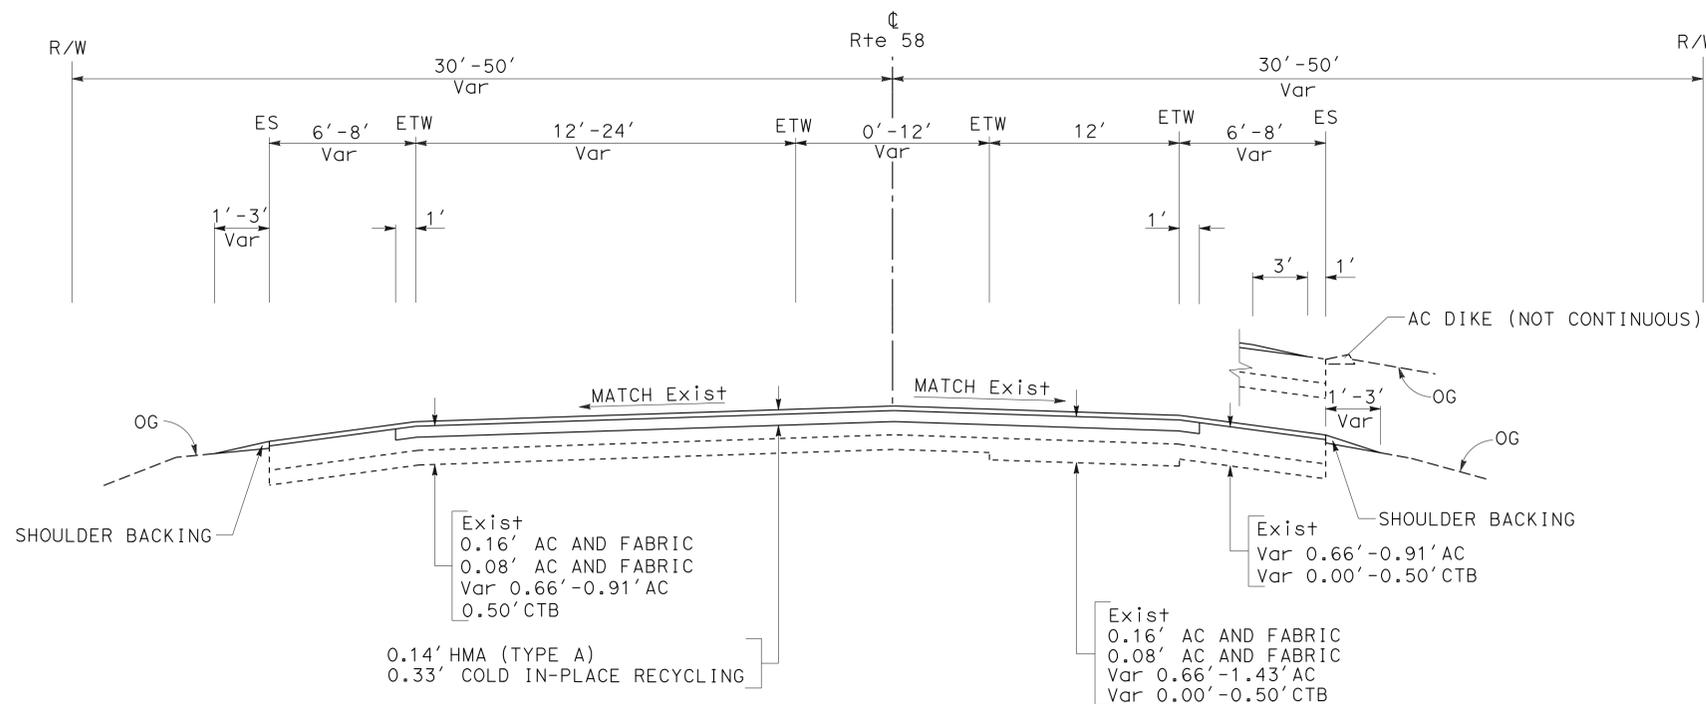

WESTBOUND **ROUTE 58** EASTBOUND  
 PM 28.200 TO PM 28.402  
 PM 28.412 TO PM 31.415

**TYPICAL CROSS SECTIONS**

NO SCALE

**X-1**

STATE OF CALIFORNIA - DEPARTMENT OF TRANSPORTATION	FUNCTIONAL SUPERVISOR	RENE SANCHEZ
<b>Caltrans</b>	CALCULATED/DESIGNED BY	ZHI ZHAN LIN
	CHECKED BY	RENE SANCHEZ
	REVISOR	
	DATE	



Dist	COUNTY	ROUTE	POST MILES TOTAL PROJECT	SHEET No.	TOTAL SHEETS
06	Ker	58	28.2/31.5	3	16


<i>Zhi Zhan Lin</i>	11-26-14
REGISTERED CIVIL ENGINEER	DATE
12-8-14	
PLANS APPROVAL DATE	

REGISTERED PROFESSIONAL ENGINEER  
**ZHI ZHAN LIN**  
 No. 60881  
 Exp. 12-31-16  
 CIVIL  
 STATE OF CALIFORNIA


THE STATE OF CALIFORNIA OR ITS OFFICERS OR AGENTS SHALL NOT BE RESPONSIBLE FOR THE ACCURACY OR COMPLETENESS OF SCANNED COPIES OF THIS PLAN SHEET.

**LEGEND:**


- HOT MIX ASPHALT (Type A)
- COLD PLANE AC PAVEMENT

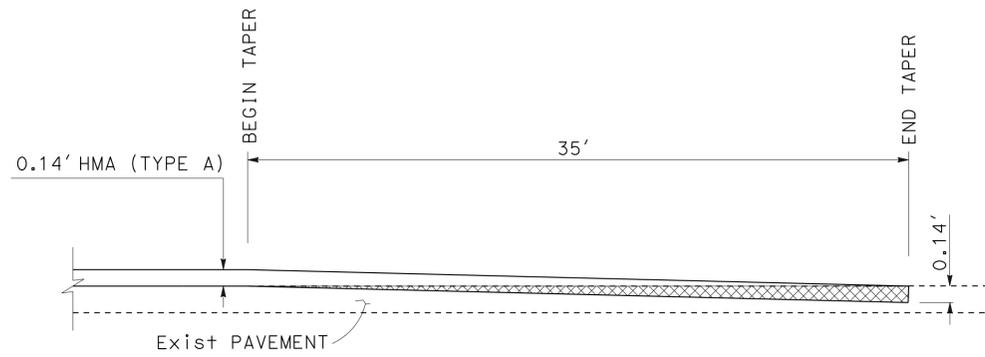


**TYPICAL TAPER AT TRANSVERSE JOINTS**  
 PM 28.200, PM 28.402, PM 28.412, PM 31.415

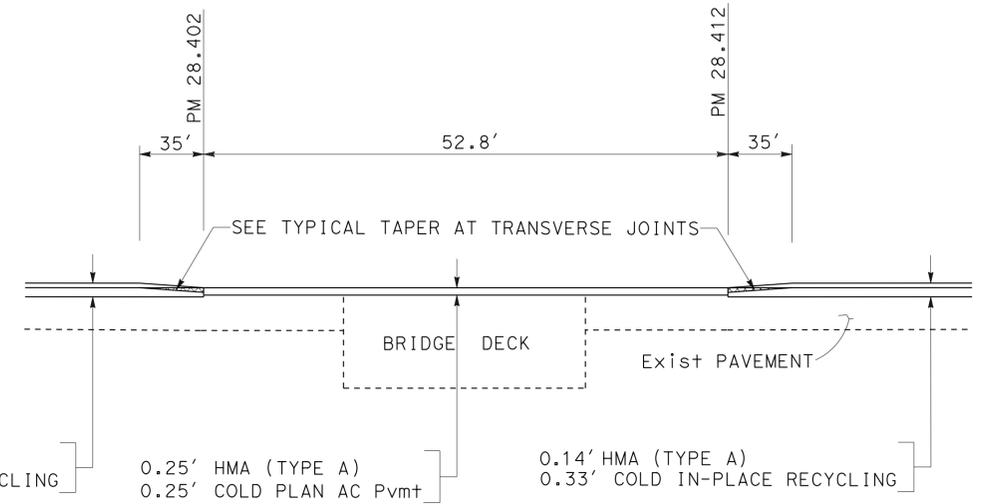

**TYPICAL TRANSITION AT BRIDGE**  
 PM 28.407 (EAST SIDE CANAL)

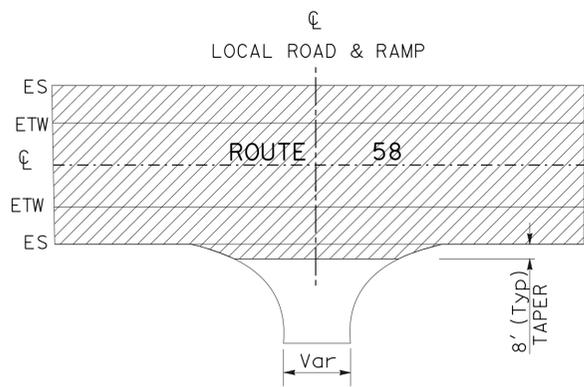

**TYPICAL INTERSECTION WORK**  
 PM 28.75, PM 30.79

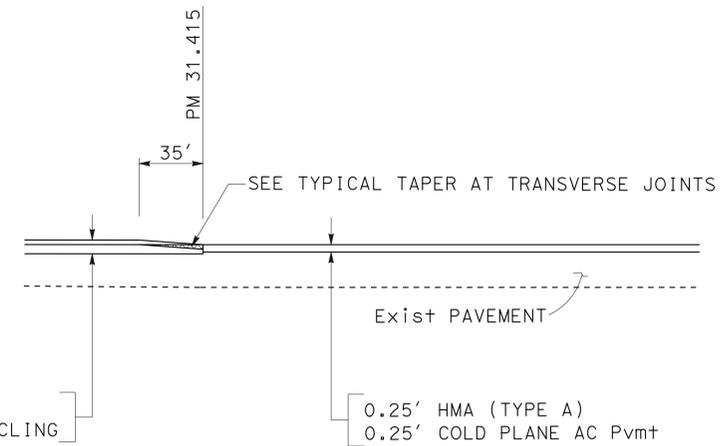

**TRANSITION AT PM 31.415**

**CONSTRUCTION DETAILS**  
**C-1**

NO SCALE

STATE OF CALIFORNIA - DEPARTMENT OF TRANSPORTATION  
**Caltrans**  
 PAVEMENT PRESERVATION  
 FUNCTIONAL SUPERVISOR: RENE SANCHEZ  
 ZHI ZHAN LIN  
 REVISOR: RENE SANCHEZ  
 REVISIONS: (None listed)  
 CALCULATED/DESIGNED BY: (None listed)  
 CHECKED BY: (None listed)

## STATIONARY MOUNTED CONSTRUCTION AREA SIGNS

SIGN No.	SIGN CODE	PANEL SIZE	SIGN MESSAGE	No. OF POST AND SIZE	No. OF SIGNS
(A)	W20-1	48" x 48"	ROAD WORK AHEAD	1- 6" x 6"	2
(B)	W20-1	36" x 36"	ROAD WORK AHEAD	1- 4" x 6"	6
(C)	G20-2	36" x 18"	END ROAD WORK	1- 4" x 4"	2

NOTES: 1. EXACT LOCATION AND POSITION OF SIGNS WILL BE DETERMINED BY THE ENGINEER.  
2. SIGNS POST LENGTH ARE APPROXIMATE, EXACT SIZE AND LENGTH WILL BE DETERMINED BY THE ENGINEER.

Dist	COUNTY	ROUTE	POST MILES TOTAL PROJECT	SHEET No.	TOTAL SHEETS
06	Ker	58	28.2/31.5	4	16

*Lia Zhi Zhan* 11-26-14  
REGISTERED CIVIL ENGINEER DATE

12-8-14  
PLANS APPROVAL DATE



THE STATE OF CALIFORNIA OR ITS OFFICERS OR AGENTS SHALL NOT BE RESPONSIBLE FOR THE ACCURACY OR COMPLETENESS OF SCANNED COPIES OF THIS PLAN SHEET.


STATE OF CALIFORNIA - DEPARTMENT OF TRANSPORTATION  
**Caltrans**  
**PAVEMENT PRESERVATION**

FUNCTIONAL SUPERVISOR  
 RENE SANCHEZ

CALCULATED/DESIGNED BY  
 CHECKED BY

ZHI ZHAN LIN  
 RENE SANCHEZ

REVISED BY  
 DATE REVISED

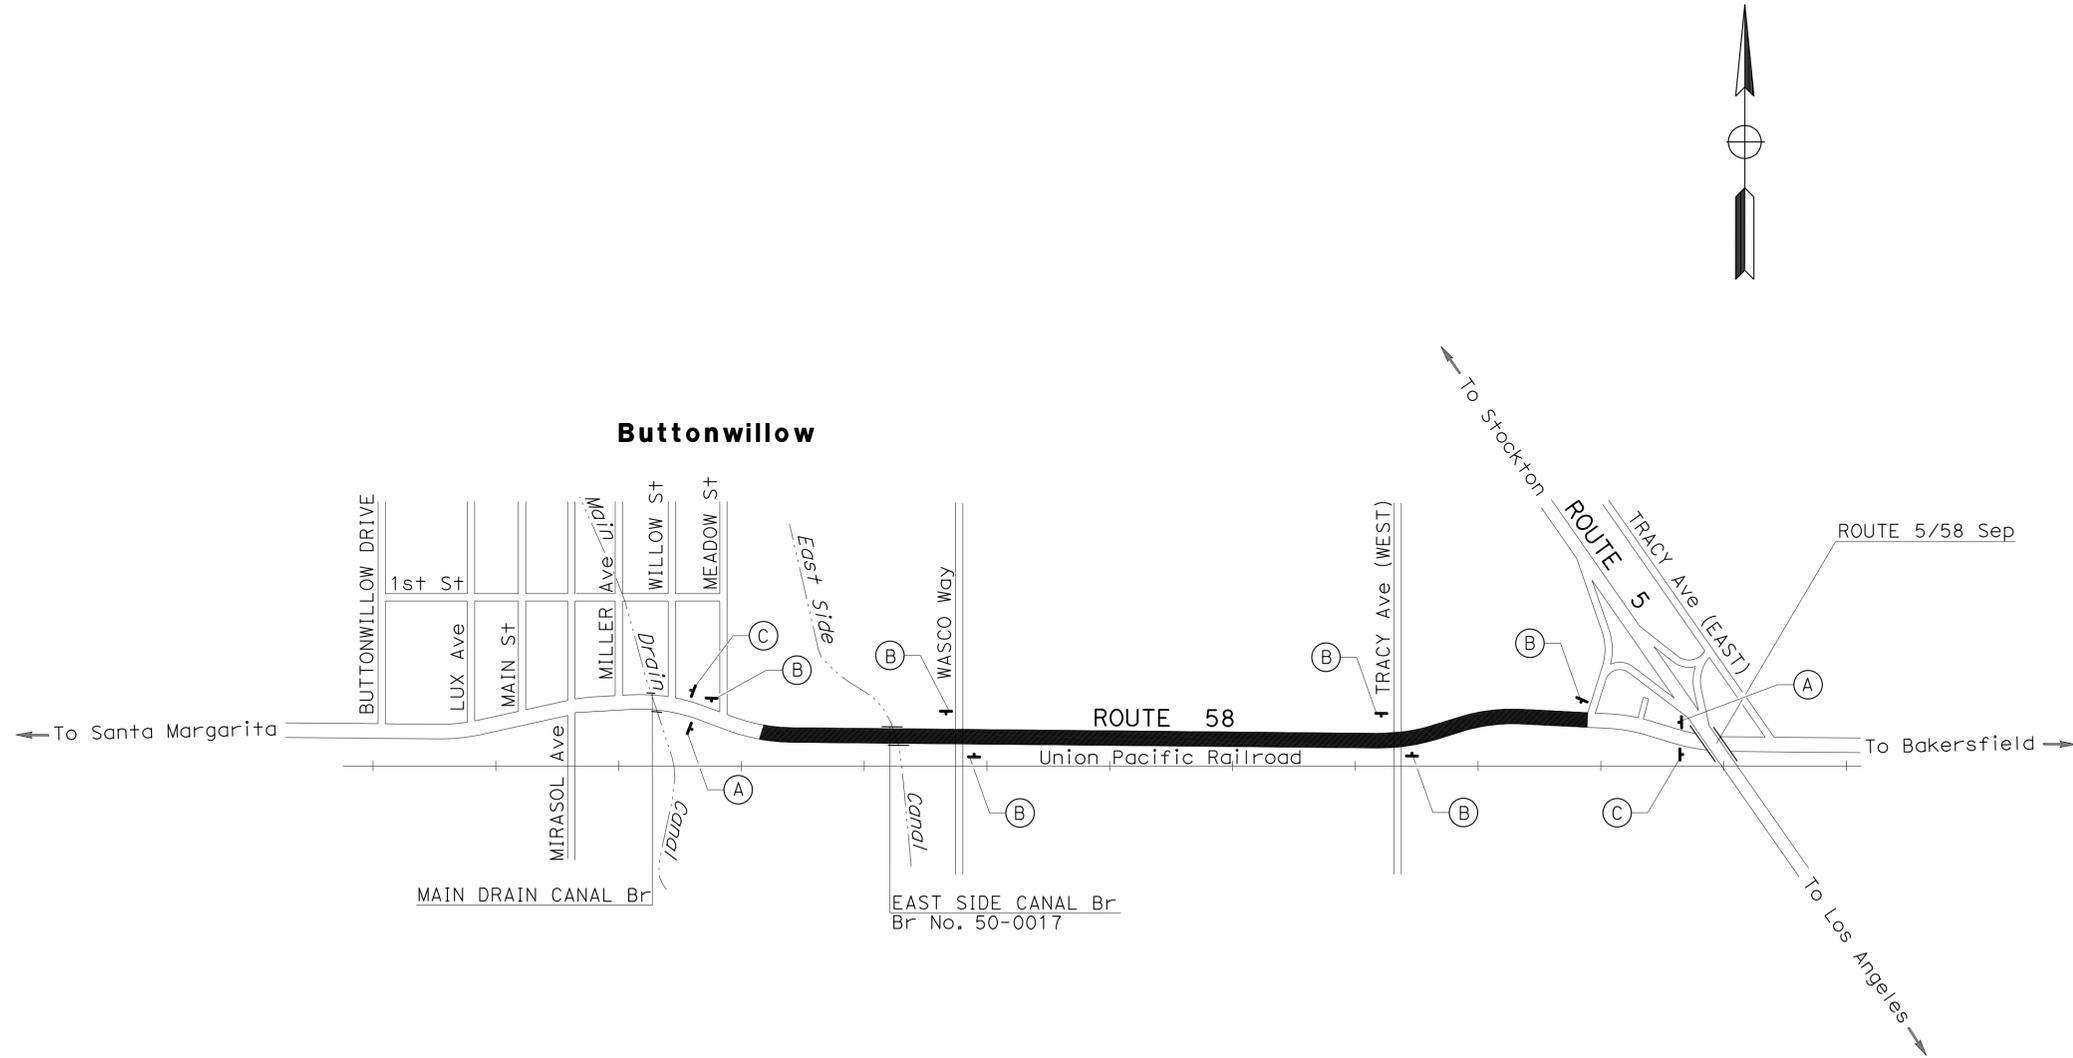

APPROVED FOR CONSTRUCTION AREA SIGN WORK ONLY

**CONSTRUCTION AREA SIGNS**  
NO SCALE  
**CS-1**

Dist	COUNTY	ROUTE	POST MILES TOTAL PROJECT	SHEET No.	TOTAL SHEETS
06	Ker	58	28.2/31.5	5	16

*Zhi Zhan Lin* 11-26-14  
 REGISTERED CIVIL ENGINEER DATE

12-8-14  
 PLANS APPROVAL DATE

THE STATE OF CALIFORNIA OR ITS OFFICERS OR AGENTS SHALL NOT BE RESPONSIBLE FOR THE ACCURACY OR COMPLETENESS OF SCANNED COPIES OF THIS PLAN SHEET.

### ROADWAY QUANTITIES

LOCATION	COLD IN-PLACE RECYCLING	CEMENT (COLD IN-PLACE RECYCLING)	EMULSIFIED RECYCLING AGENT (COLD IN-PLACE RECYCLING)	ASPHALTIC EMULSION (COLD IN-PLACE RECYCLING)	SAND COVER (COLD IN-PLACE RECYCLING)	HOT MIX ASPHALT (TYPE A)	COLD PLANE ASPHALT PAVEMENT	SHOULDER BACKING	TACK COAT
	SQYD	TON	TON	TON	TON	TON	SQYD	TON	TON
ROUTE 58 PM 28.2/31.5 EASTBOUND	27,950	16	152	5	30	3885	975	165	9
ROUTE 58 PM 28.2/31.5 WESTBOUND	27,950	16	152	5	30	3885	975	165	10
TOTAL	55,900	32	304	10	60	7770	1950	330	19

### PAVEMENT DELINEATION QUANTITIES

LOCATION	DETAIL	THERMOPLASTIC TRAFFIC STRIPE					PAVEMENT MARKER (RETROREFLECTIVE)			REMOVE PAVEMENT MARKER	THERMOPLASTIC PAVEMENT MARKING		
		4" YELLOW	4" WHITE	4" (BROKEN 36-12)	4" (BROKEN 12-3)	8" WHITE	TYPE D TWO-WAY YELLOW	TYPE G ONE-WAY CLEAR	TYPE H ONE-WAY YELLOW		EA	EA	EA
		LF	LF	LF	LF	LF	EA	EA	EA		EA	EA	EA
ROUTE 58 PM 28.2/31.5 EASTBOUND	6			11,725			250			250	24'-LIMIT LINE	24	
	19	2270		2270			51		98	149	1-TYPE III (L) ARROW	42	
	22	2842					127			127	1-SIGNAL HEAD	63	
	27B		17,189										
	27C				50								
	29	6800					149			149			
ROUTE 58 PM 28.2/31.5 WESTBOUND	38					240		13		13			
	27B		17,300								52'-LIMIT LINE	52	
	27C				40						2-TYPE III (L) ARROW	84	
	38					685		31	31		2-TYPE VI ARROW	84	
SUBTOTAL		11,912	34,489				577	44	98				
TOTAL			46,401	13,995	90	925			719	719		349	

## SUMMARY OF QUANTITIES Q-1

Dist	COUNTY	ROUTE	POST MILES TOTAL PROJECT	SHEET No.	TOTAL SHEETS
06	Ker	58	28.2/31.5	6	16

David C. Arias 11-15-14  
 REGISTERED ELECTRICAL ENGINEER DATE  
 12-8-14  
 PLANS APPROVAL DATE

THE STATE OF CALIFORNIA OR ITS OFFICERS OR AGENTS SHALL NOT BE RESPONSIBLE FOR THE ACCURACY OR COMPLETENESS OF SCANNED COPIES OF THIS PLAN SHEET.



REGISTERED PROFESSIONAL ENGINEER  
 David C. Arias  
 No. 15559  
 Exp. 12/31/15  
 ELECTRICAL  
 STATE OF CALIFORNIA

**LEGEND:**

- 1 Exist 120/240 V, TYPE III-CF SERVICE EQUIPMENT ENCLOSURE.
- 2 Exist MODEL 170E CONTROLLER ASSEMBLY.

**NOTE:**


FOR ACCURATE RIGHT OF WAY DATA, CONTACT RIGHT OF WAY ENGINEERING AT THE DISTRICT OFFICE.

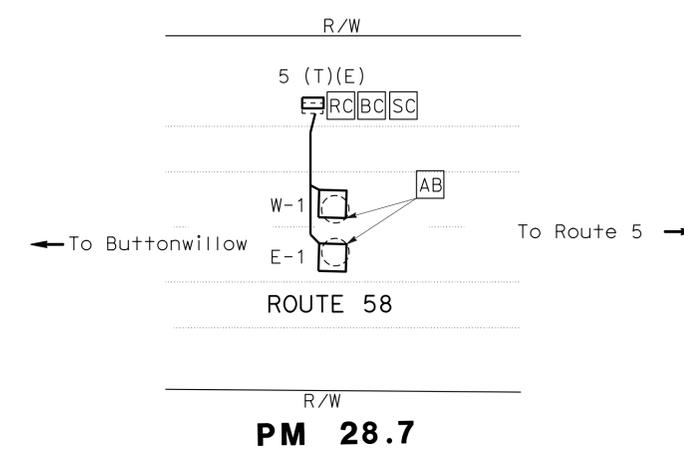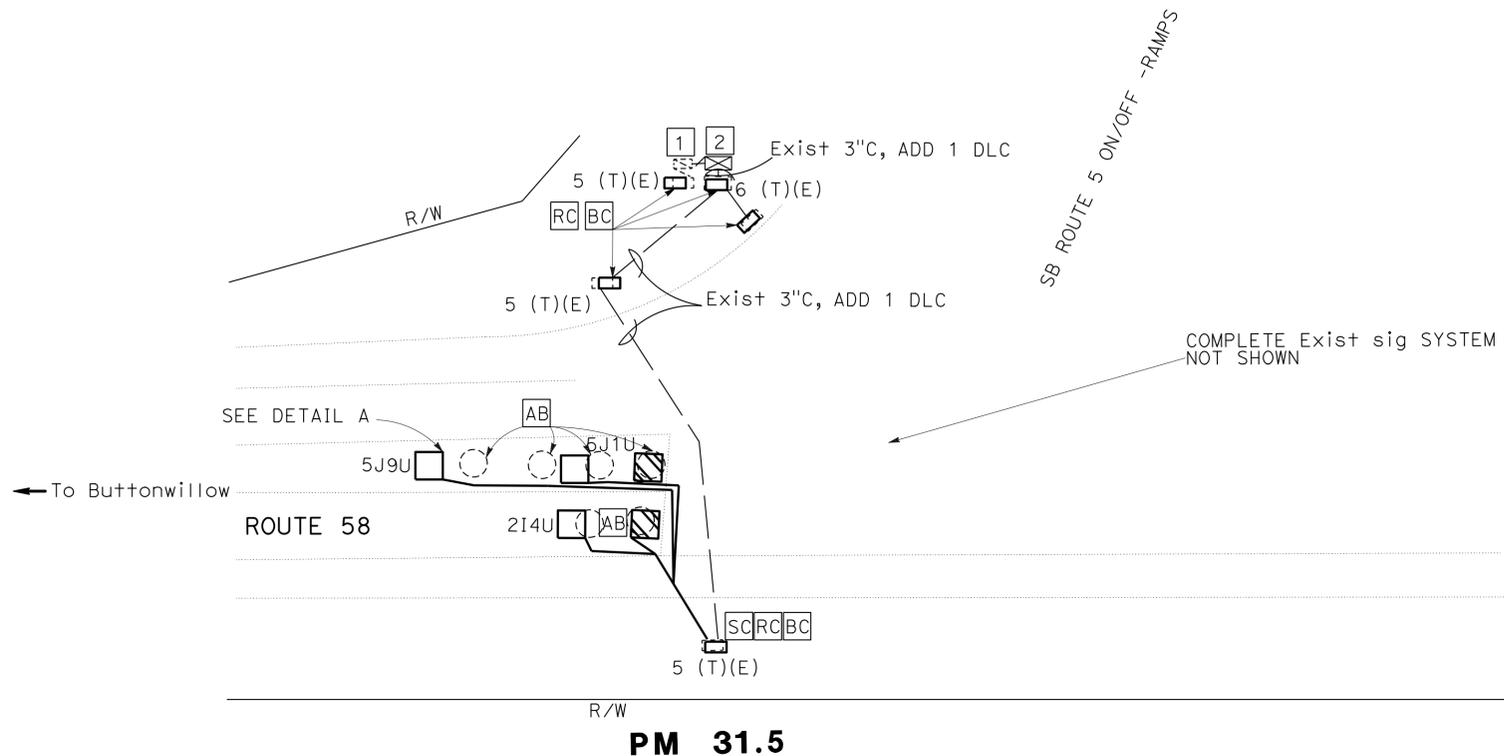


**MODIFY SIGNAL AND COUNT STATION**

SHEET No.	DLC	No. 6 (T)(E) PB	No. 5(T)(E) PB	TYPE A DETECTOR LOOP	TYPE D DETECTOR LOOP
E-1	LF	1	5	EA	2

THE QUANTITIES SHOWN IN THE TABLE ARE NOT A SEPARATE PAY ITEM, FOR INFORMATION ONLY. FOR COMPLETE ELECTRICAL WORK, SEE ELECTRICAL PLAN SHEETS.

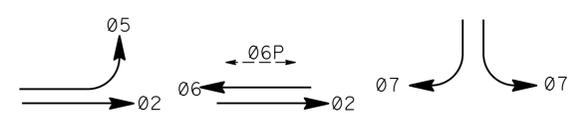

 **PHASE DIAGRAM**  
STEADY DEMAND SEQUENCE



**DETAIL A**  
DETECTOR LOOP SPACING (LEFT TURN ONLY)  
NO SCALE

**MODIFY SIGNAL AND COUNT STATION E-1**

APPROVED FOR ELECTRICAL WORK ONLY

SCALE: 1" = 20'

STATE OF CALIFORNIA - DEPARTMENT OF TRANSPORTATION  
 Et Caltrans MAINTENANCE DESIGN  
 FUNCTIONAL SUPERVISOR FRANK GONZALEZ  
 CALCULATED/DESIGNED BY CHECKED BY DAVID C. ARIAS  
 REVISED BY DATE REVISED DAVID ARIAS 12-08-14

LAST REVISION DATE PLOTTED => 14-JAN-2015 12-08-14 TIME PLOTTED => 10:58

Dist	COUNTY	ROUTE	POST MILES TOTAL PROJECT	SHEET No.	TOTAL SHEETS
06	Ker	58	28.2/31.5	7	16

*Grace M. Tsushima*  
REGISTERED CIVIL ENGINEER

July 19, 2013  
PLANS APPROVAL DATE

THE STATE OF CALIFORNIA OR ITS OFFICERS OR AGENTS SHALL NOT BE RESPONSIBLE FOR THE ACCURACY OR COMPLETENESS OF SCANNED COPIES OF THIS PLAN SHEET.

TO ACCOMPANY PLANS DATED 12-8-14

**UNIT OF MEASUREMENT SYMBOLS:**

Some of the symbols used in the project plan quantity tables and in the Bid Item List are:

**TABLE A**

SYMBOL USED	DEFINITIONS
ACRE	ACRE
CF	CUBIC FOOT
CY	CUBIC YARD
EA	EACH
GAL	GALLON
LB	POUND
LF	LINEAR FOOT
SQFT	SQUARE FOOT
SQYD	SQUARE YARD
STA	100 FEET
TAB	TABLET
TON	2,000 POUNDS

Some of the symbols used in the plans other than in the project plan quantity tables are:

**TABLE B**

SYMBOL USED	DEFINITIONS
ksi	KIPS PER SQUARE INCH
ksf	KIPS PER SQUARE FOOT
psi	POUNDS PER SQUARE INCH
psf	POUNDS PER SQUARE FOOT
lb/ft <sup>3</sup> , pcf	POUNDS PER CUBIC FOOT
tsf	TONS PER SQUARE FOOT
mph, MPH *	MILES PER HOUR
ø	NOMINAL DIAMETER
oz	OUNCE
lb	POUND
kíp	1,000 POUNDS
cal	CALORIE
ft	FOOT OR FEET
gal	GALLON

\* For use on a sign panel only

STATE OF CALIFORNIA  
DEPARTMENT OF TRANSPORTATION

**ABBREVIATIONS  
(SHEET 2 OF 2)**

NO SCALE

RSP A10B DATED JULY 19, 2013 SUPERSEDES STANDARD PLAN A10B  
DATED MAY 20, 2011 - PAGE 2 OF THE STANDARD PLANS BOOK DATED 2010.

**REVISED STANDARD PLAN RSP A10B**

Maint	MAINTENANCE
Max	MAXIMUM
MB	METAL BEAM
MBB	METAL BEAM BARRIER
MBGR	METAL BEAM GUARD RAILING
Med	MEDIAN
MGS	MIDWEST GUARDRAIL SYSTEM
MH	MANHOLE
Min	MINIMUM
Misc	MISCELLANEOUS
Misc I & S	MISCELLANEOUS IRON AND STEEL
Mkr	MARKER
Mod	MODIFIED, MODIFY
Mon	MONUMENT
MP	METAL PLATE
MPGR	METAL PLATE GUARD RAILING
MR	MOVEMENT RATING
MSE	MECHANICALLY STABILIZED EMBANKMENT
Mt	MOUNTAIN, MOUNT
MtI	MATERIAL
MVP	MAINTENANCE VEHICLE PULLOUT
<b>N</b>	
N	NORTH
NB	NORTHBOUND
No.	NUMBER (MUST HAVE PERIOD)
Nos.	NUMBERS (MUST HAVE PERIOD)
NPS	NOMINAL PIPE SIZE
NS	NEAR SIDE
NSP	NEW STANDARD PLAN
NTS	NOT TO SCALE
<b>O</b>	
Obir	OBLITERATE
OC	OVERCROSSING
OD	OUTSIDE DIAMETER
OF	OUTSIDE FACE
OG	ORIGINAL GROUND
OGAC	OPEN GRADED ASPHALT CONCRETE
OGFC	OPEN GRADED FRICTION COURSE
OH	OVERHEAD
OHWM	ORDINARY HIGH WATER MARK
O-O	OUT TO OUT
Opp	OPPOSITE
OSD	OVERSIDE DRAIN
<b>P</b>	
p	PAGE
PAP	PERFORATED ALUMINUM PIPE
PB	PULL BOX
PC	POINT OF CURVATURE, PRECAST
PCC	POINT OF COMPOUND CURVE, PORTLAND CEMENT CONCRETE
PCMS	PORTABLE CHANGEABLE MESSAGE SIGN
PCP	PERFORATED CONCRETE PIPE, PRESTRESSED CONCRETE PIPE
PCVC	POINT OF COMPOUND VERTICAL CURVE
PEC	PERMIT TO ENTER AND CONSTRUCT
Ped	PEDESTRIAN
Ped OC	PEDESTRIAN OVERCROSSING
Ped UC	PEDESTRIAN UNDERCROSSING
Perm MtI	PERMEABLE MATERIAL

<b>P continued</b>	
PG	PROFILE GRADE
PI	POINT OF INTERSECTION
PJP	PARTIAL JOINT PENETRATION
Pkwy	PARKWAY
PL, PL	PLATE
P/L	PROPERTY LINE
PM	POST MILE, TIME FROM NOON TO MIDNIGHT
PN	PAVING NOTCH
POC	POINT OF HORIZONTAL CURVE
POT	POINT OF TANGENT
POVC	POINT OF VERTICAL CURVE
PP	PIPE PILE, PLASTIC PIPE, POWER POLE
PPL	PERFORMED PERMEABLE LINER
PPP	PERFORATED PLASTIC PIPE
PRC	POINT OF REVERSE CURVE
PRF	PAVEMENT REINFORCING FABRIC
PRVC	POINT OF REVERSE VERTICAL CURVE
PS&E	PLANS, SPECIFICATIONS AND ESTIMATES
PS, P/S	PRESTRESSED
PSP	PERFORATED STEEL PIPE
PT	POINT OF TANGENCY
PVC	POLYVINYL CHLORIDE
Pvmt	PAVEMENT
<b>Q</b>	
Qty	QUANTITY
<b>R</b>	
R	RADIUS
R & D	REMOVE AND DISPOSE
R & S	REMOVE AND SALVAGE
R/C	RATE OF CHANGE
RCA	REINFORCED CONCRETE ARCH
RCB	REINFORCED CONCRETE BOX
RCP	REINFORCED CONCRETE PIPE
RCPA	REINFORCED CONCRETE PIPE ARCH
Rd	ROAD
Reinf	REINFORCED, REINFORCEMENT, REINFORCING
Rel	RELOCATE
Repl	REPLACEMENT
Ret	RETAINING
Rev	REVISED, REVISION
Rdwy	ROADWAY
RHMA	RUBBERIZED HOT MIX ASPHALT
Riv	RIVER
RM	ROAD-MIXED
RP	RADIUS POINT, REFERENCE POINT
RR	RAILROAD
RSP	ROCK SLOPE PROTECTION, REVISED STANDARD PLAN
Rt	RIGHT
Rte	ROUTE
RW	REDWOOD, RETAINING WALL
R/W	RIGHT OF WAY
Rwy	RAILWAY

<b>S</b>	
S	SOUTH, SUPPLEMENT
SAE	STRUCTURE APPROACH EMBANKMENT
Salv	SALVAGE
SAPP	STRUCTURAL ALUMINUM PLATE PIPE
SB	SOUTHBOUND
SC	SAND CUSHION
SCSP	SLOTTED CORRUGATED STEEL PIPE
SD	STORM DRAIN
Sec	SECOND, SECTION
Sep	SEPARATION
SG	SUBGRADE
Shld	SHOULDER
Sht	SHEET
Sim	SIMILAR
SL	STATION LINE
SM	SELECTED MATERIAL
Spec	SPECIAL, SPECIFICATIONS
SPP	SLOTTED PLASTIC PIPE
SS	SLOPE STAKE
SSBM	STRAP AND SADDLE BRACKET METHOD
SSD	STRUCTURAL SECTION DRAIN
SSPA	STRUCTURAL STEEL PLATE ARCH
SSPP	STRUCTURAL STEEL PLATE PIPE
SSPPA	STRUCTURAL STEEL PLATE PIPE ARCH
SSRP	STEEL SPIRAL RIB PIPE
St	STREET
Sta	STATION
STBB	SINGLE THRIE BEAM BARRIER
Std	STANDARD
Str	STRUCTURE
Surf	SURFACING
SW	SIDEWALK, SOUND WALL
Swr	SEWER
Sym	SYMMETRICAL
S4S	SURFACE 4 SIDES
<b>T</b>	
T	SEMI-TANGENT
Tan	TANGENT
TBB	THRIE BEAM BARRIER
Tbr	TIMBER
TC	TOP OF CURB
TCB	TRAFFIC CONTROL BOX
TCE	TEMPORARY CONSTRUCTION EASEMENT
Tel	TELEPHONE
Temp	TEMPORARY
TG	TOP OF GRADE
Tot	TOTAL
TP	TELEPHONE POLE
TPB	TREATED PERMEABLE BASE
TPM	TREATED PERMEABLE MATERIAL
Trans	TRANSITION

<b>T continued</b>	
TS	TRANSVERSE, TRAFFIC SIGNAL, TUBULAR STEEL
Typ	TYPICAL
<b>U</b>	
UC	UNDERCROSSING
UD	UNDERDRAIN
UG	UNDERGROUND
UON	UNLESS OTHERWISE NOTED
UP	UNDERPASS
<b>V</b>	
V	VALVE, DESIGN SPEED
Var	VARIABLE, VARIES
VC	VERTICAL CURVE
VCP	VITRIFIED CLAY PIPE
Vert	VERTICAL
Via	VIADUCT
Vol	VOLUME
<b>W</b>	
W	WEST, WIDTH
WB	WESTBOUND
WH	WEEP HOLE
WM	WIRE MESH
WS	WATER SURFACE
WSP	WELDED STEEL PIPE
Wt	WEIGHT
WV	WATER VALVE
WW	WINGWALL
WWLOL	WINGWALL LAYOUT LINE
<b>X</b>	
X Sec	CROSS SECTION
Xing	CROSSING
<b>Y</b>	
Yr	YEAR
Yrs	YEARS


Dist	COUNTY	ROUTE	POST MILES TOTAL PROJECT	SHEET No.	TOTAL SHEETS
06	Ker	58	28.2/31.5	8	16

Registered Professional Engineer  
**Roberta L. McLaughlin**  
 No. C40375  
 Exp. 3-31-13  
 CIVIL  
 STATE OF CALIFORNIA


April 20, 2012  
 PLANS APPROVAL DATE

THE STATE OF CALIFORNIA OR ITS OFFICERS  
 OR AGENTS SHALL NOT BE RESPONSIBLE FOR  
 THE ACCURACY OR COMPLETENESS OF SCANNED  
 COPIES OF THIS PLAN SHEET.


TO ACCOMPANY PLANS DATED 12-8-14

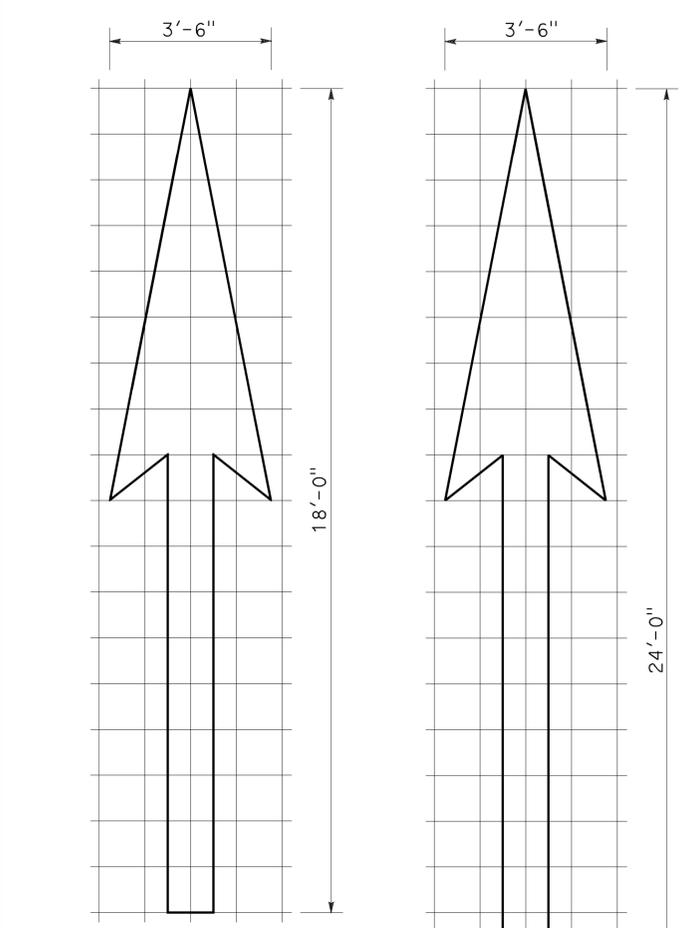


A=25 ft<sup>2</sup>  
**TYPE I 18'-0" ARROW**

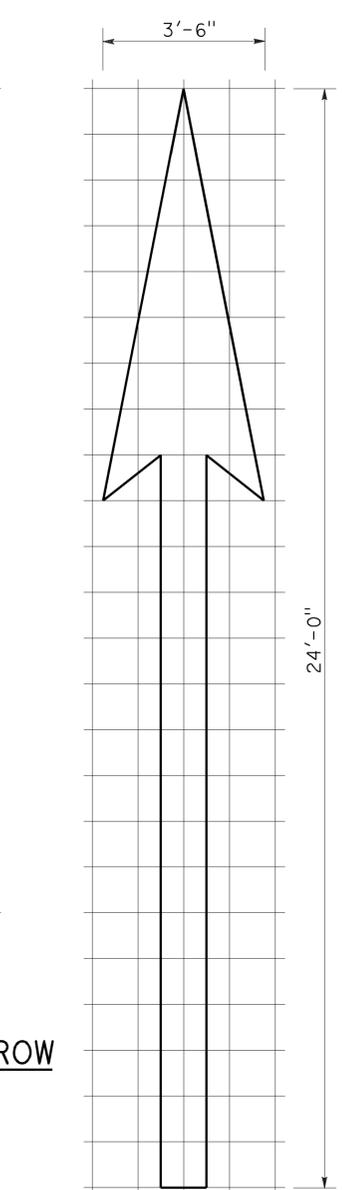


A=31 ft<sup>2</sup>  
**TYPE I 24'-0" ARROW**

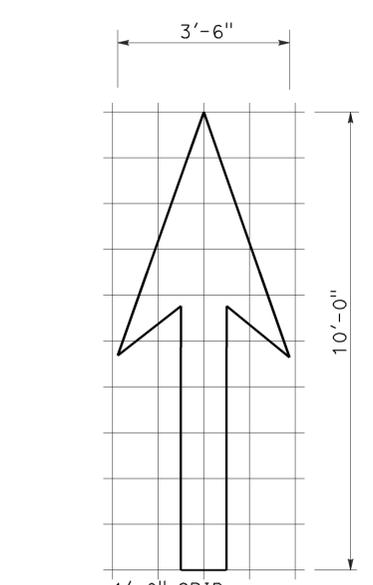


A=14 ft<sup>2</sup>  
**TYPE I 10'-0" ARROW**

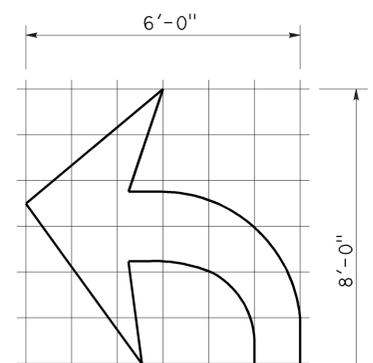


A=15 ft<sup>2</sup>  
**TYPE IV (L) ARROW**  
 (For Type IV (R) arrow,  
 use mirror image)

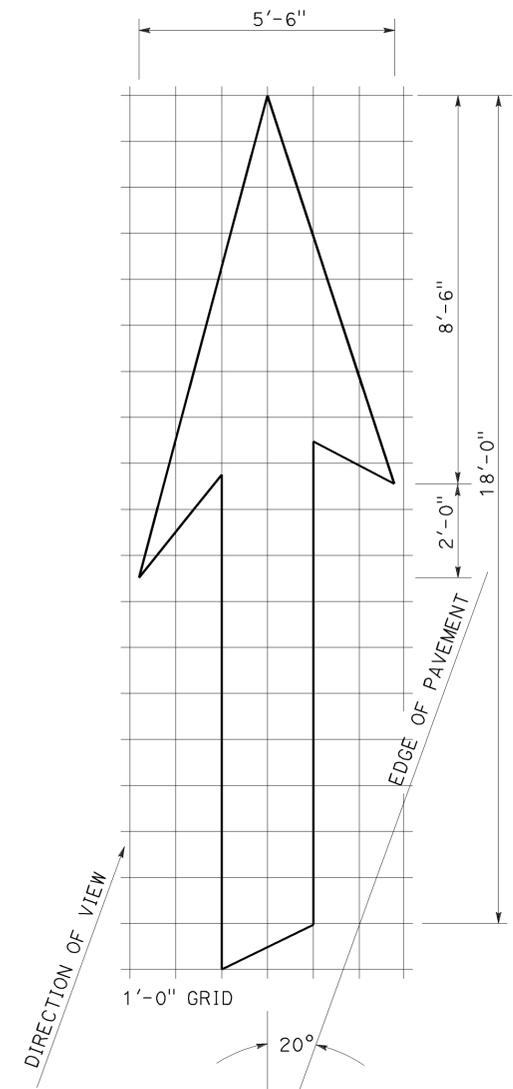


A=42 ft<sup>2</sup>  
**TYPE VI ARROW**  
 Right lane drop arrow  
 (For left lane,  
 use mirror image)

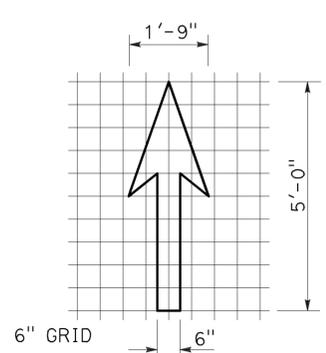


A=3.5 ft<sup>2</sup>  
**BIKE LANE ARROW**

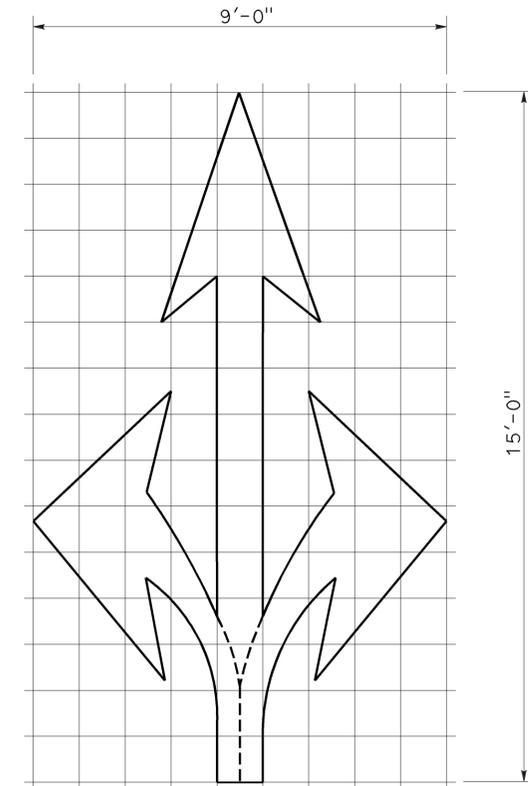

A=36 ft<sup>2</sup>  
**TYPE VIII ARROW**

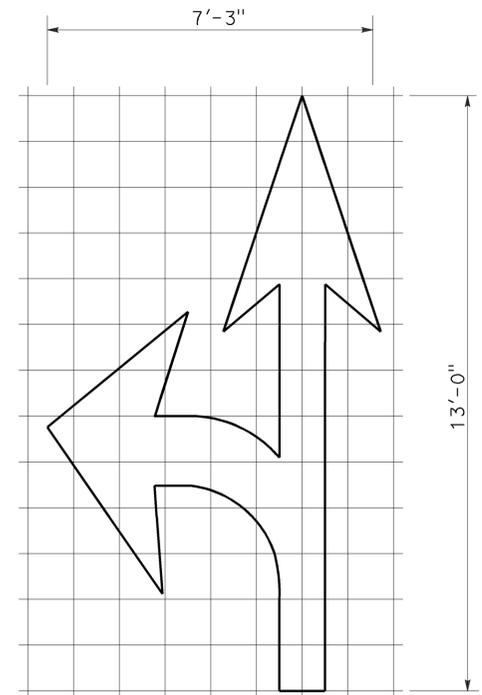

A=27 ft<sup>2</sup>  
**TYPE VII (L) ARROW**  
 (For Type VII (R) arrow,  
 use mirror image)

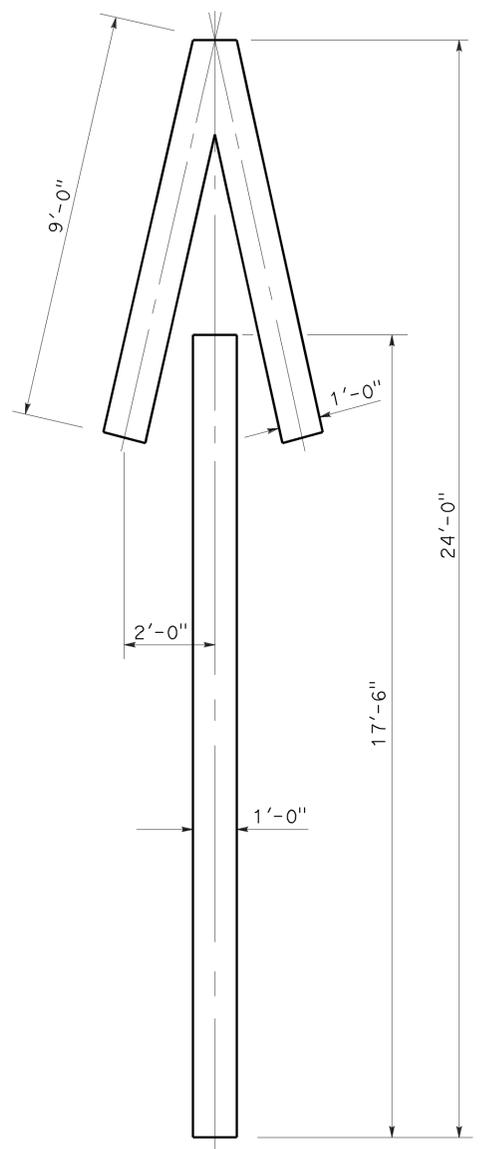

A=33 ft<sup>2</sup>  
**TYPE V ARROW**

**NOTE:**  
 Minor variations in dimensions  
 may be accepted by the Engineer.


STATE OF CALIFORNIA  
 DEPARTMENT OF TRANSPORTATION  
**PAVEMENT MARKINGS  
 ARROWS**  
 NO SCALE

RSP A24A DATED APRIL 20, 2012 SUPERSEDES STANDARD PLAN A24A  
 DATED MAY 20, 2011 - PAGE 13 OF THE STANDARD PLANS BOOK DATED 2010.


**REVISED STANDARD PLAN RSP A24A**

2010 REVISED STANDARD PLAN RSP A24A


TO ACCOMPANY PLANS DATED 12-8-14

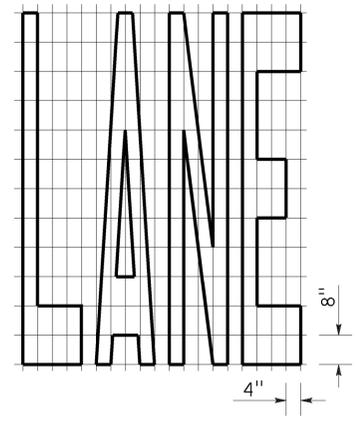


A=24 ft<sup>2</sup>

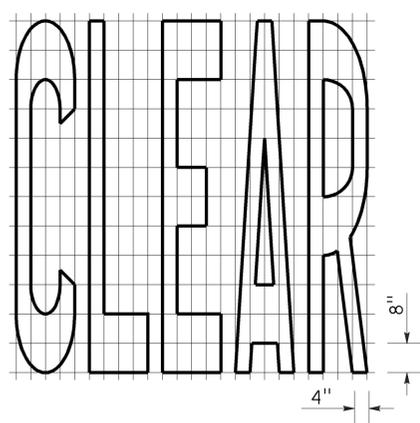


A=27 ft<sup>2</sup>

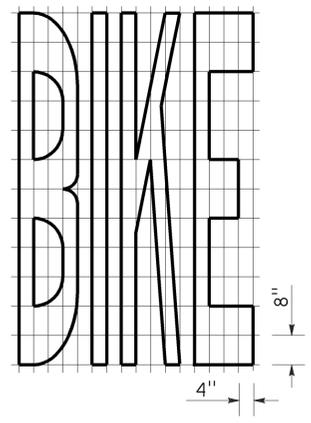


A=21 ft<sup>2</sup>

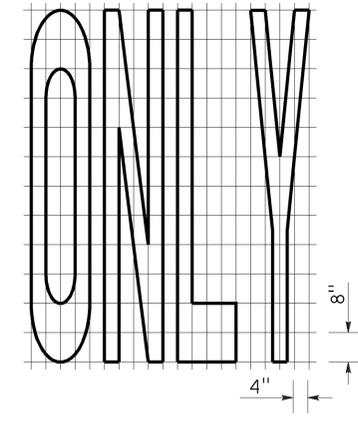


A=22 ft<sup>2</sup>

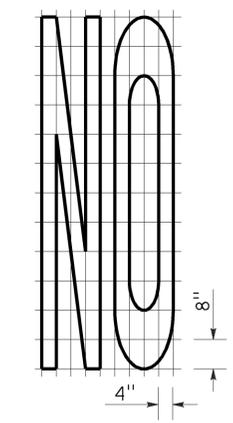


A=14 ft<sup>2</sup>

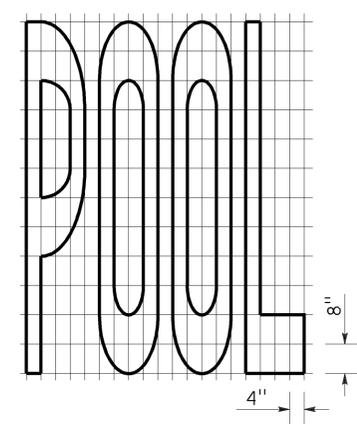


A=23 ft<sup>2</sup>

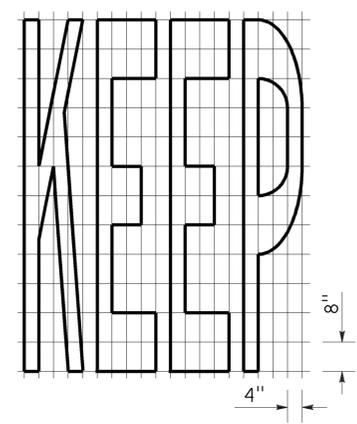


A=24 ft<sup>2</sup>

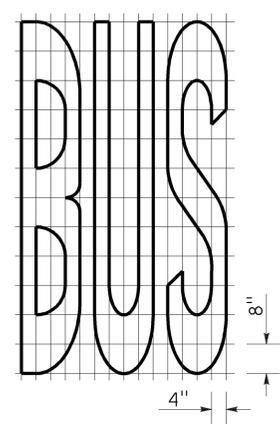

A=20 ft<sup>2</sup>


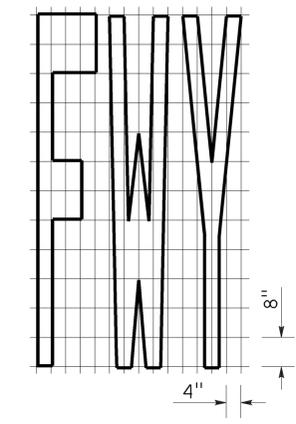


A=16 ft<sup>2</sup>

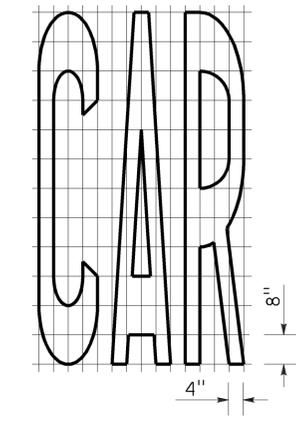


A=17 ft<sup>2</sup>


WORD MARKINGS			
ITEM	ft <sup>2</sup>	ITEM	ft <sup>2</sup>
LANE	24	NO	14
POOL	23	BIKE	21
CAR	17	BUS	20
CLEAR	27	ONLY	22
KEEP	24	FWY	16

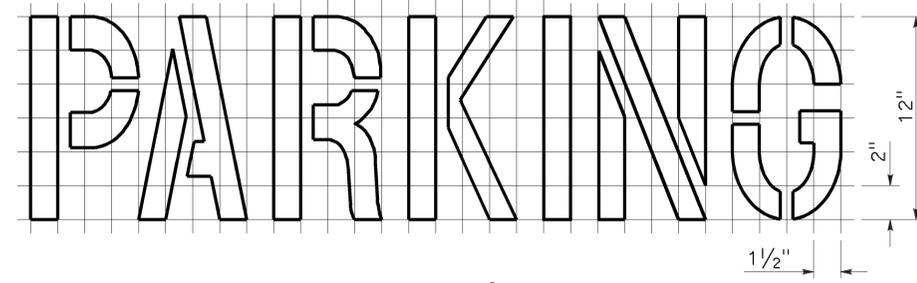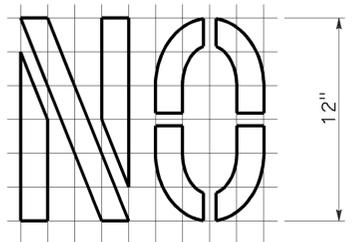

A=2 ft<sup>2</sup>  
See Notes 6 and 7

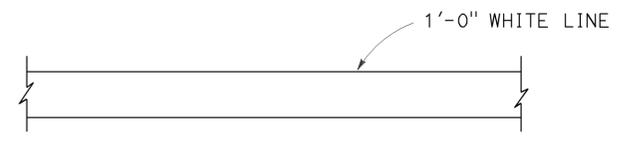

LIMIT LINE (STOP LINE)

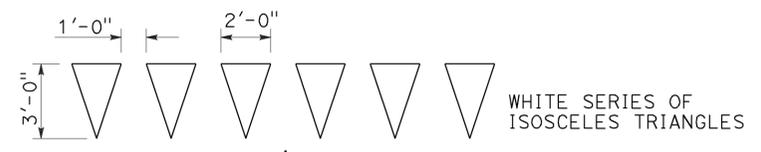

DIRECTION OF TRAVEL  
YIELD LINE

**NOTES:**

1. If a message consists of more than one word, it should read "UP", i.e., the first word should be nearest the driver.
2. The space between words should be at least four times the height of the characters for low speed roads, but not more than ten times the height of the characters. The space may be reduced appropriately where there is limited space because of local conditions.
3. Minor variations in dimensions may be accepted by the Engineer.
4. Portions of a letter, number or symbol may be separated by connecting segments not to exceed 2" in width.
5. The words "NO PARKING" pavement marking is to be used for parking facilities. For typical locations of markings, see Standard Plans A90A and A90B.
6. The words "NO PARKING", shall be painted in white letters no less than 1'-0" high on a contrasting background and located so that it is visible to traffic enforcement officials.

STATE OF CALIFORNIA  
DEPARTMENT OF TRANSPORTATION  
**PAVEMENT MARKINGS  
WORDS, LIMIT AND YIELD LINES**  
NO SCALE

RSP A24E DATED JULY 20, 2012 SUPERSEDES STANDARD PLAN A24E  
DATED MAY 20, 2011 - PAGE 17 OF THE STANDARD PLANS BOOK DATED 2010.

2010 REVISED STANDARD PLAN RSP A24E

**NOTES:**

See Revised Standard Plan RSP T9 for tables.


Use cone spacing X for taper segment, Y for tangent segment or Z for conflict situations, as appropriate, per Table 1, unless X, Y, or Z cone spacing is shown on this sheet.

Unless otherwise specified in the special provisions, all temporary warning signs shall have black legend on fluorescent orange background.

California codes are designated by (CA). Otherwise, Federal (MUTCD) codes are shown.

**TYPICAL LANE CLOSURE WITH REVERSIBLE CONTROL**

TO ACCOMPANY PLANS DATED 12-8-14

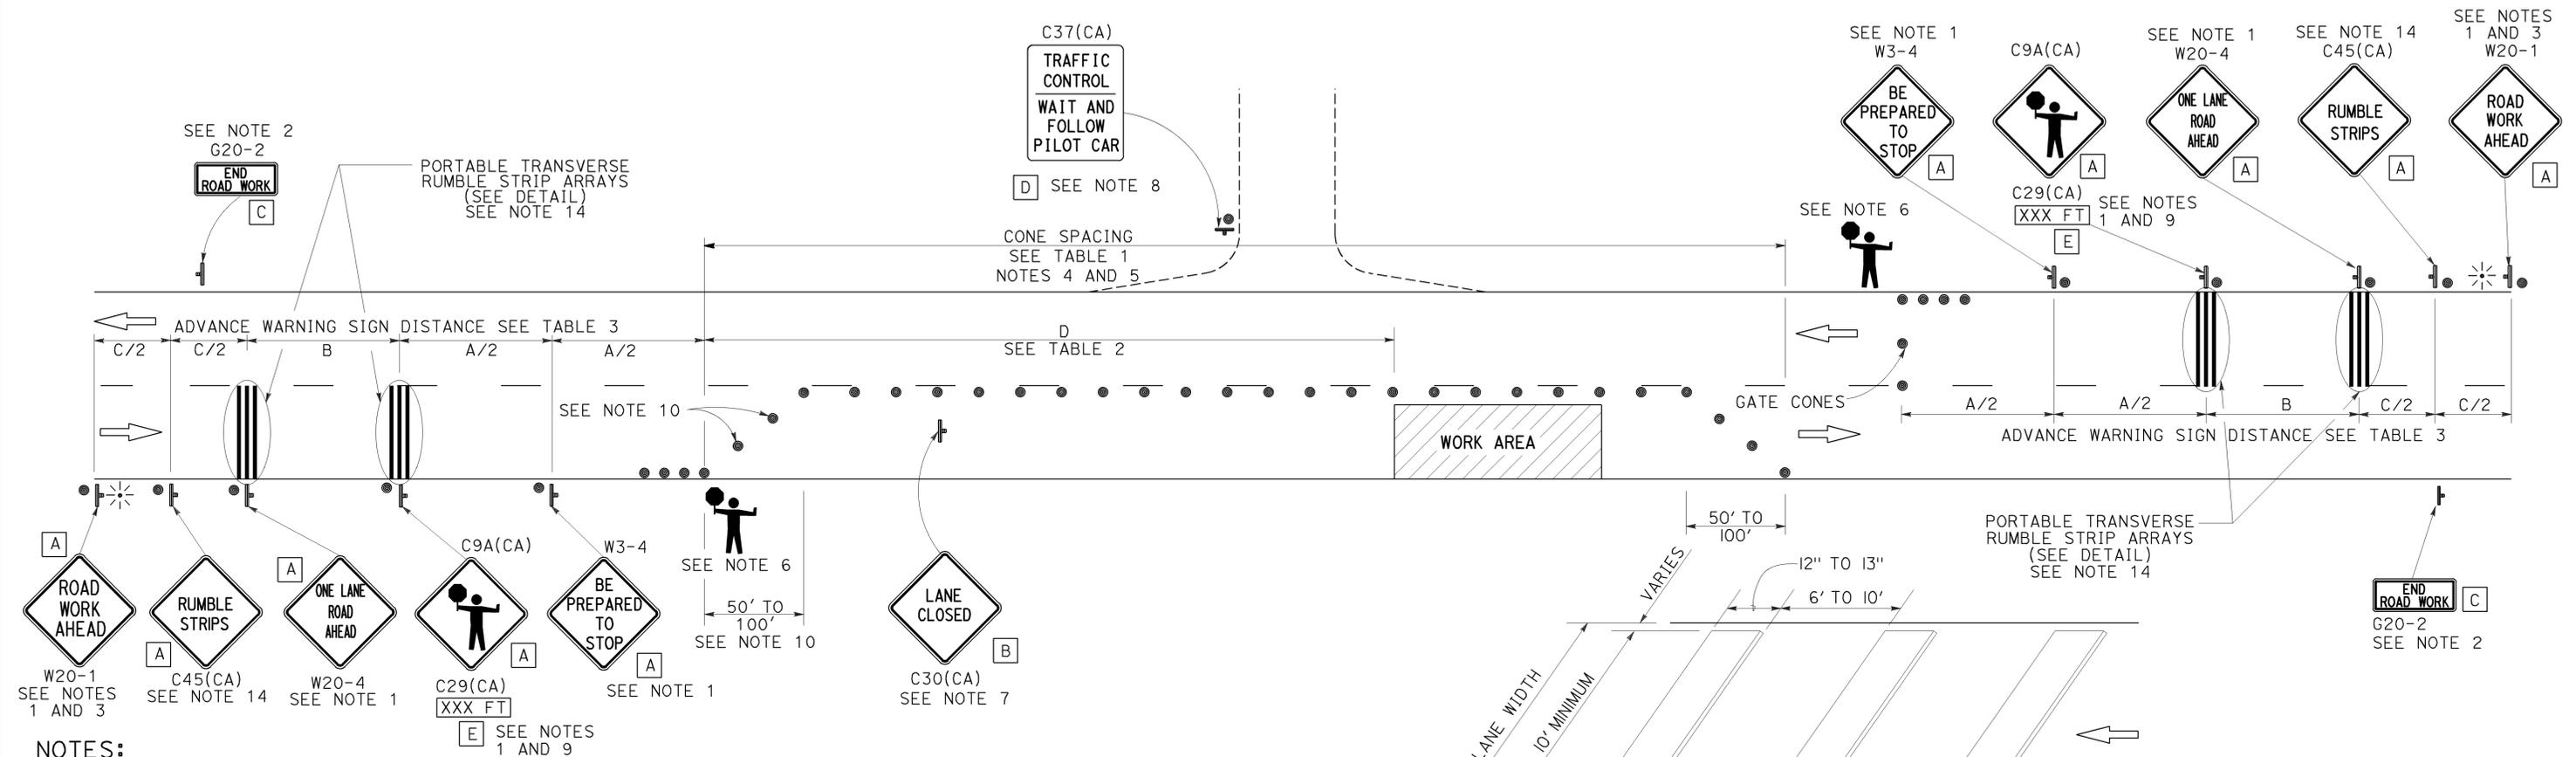

- NOTES:**
- Each advance warning sign in each direction of travel shall be equipped with at least two flags for daytime closure. Each flag shall be at least 16" x 16" in size and shall be orange or fluorescent red-orange in color. Flashing beacons shall be placed at the locations indicated for lane closure during hours of darkness.
  - A G20-2 "END ROAD WORK" sign, as appropriate, shall be placed at the end of the lane control unless the end of work area is obvious, or ends within a larger project's limits.
  - If the W20-1 sign would follow within 2000' of a stationary W20-1 or G20-1 "ROAD WORK NEXT \_\_\_\_\_ MILES", use a W20-4 sign for the first advance warning sign.
  - All cones used for lane closures during the hours of darkness shall be fitted with retroreflective bands (or sleeves) as specified in the specifications.
  - Portable delineators, placed at one-half the spacing indicated for traffic cones, may be used instead of cones for daytime closures only.
  - Additional advance flaggers may be required. Flagger should stand in a conspicuous place, be visible to approaching traffic as well as approaching vehicles after the first vehicle has stopped. During the hours of darkness, the flagging-station and flagger shall be illuminated and clearly visible to approaching traffic. The illumination footprint of the lighting on the ground shall be at least 20' in diameter. Place a minimum of four cones at 50' intervals in advance of flagger station as shown.

- Place C30(CA) "LANE CLOSED" sign at 500' to 1000' intervals throughout extended work areas. They are optional if the work area is visible from the flagger station.
- When a pilot car is used, place a C37(CA) "TRAFFIC CONTROL-WAIT AND FOLLOW PILOT CAR" sign with black legend on white background at all intersections, driveways and alleys without a flagger within traffic control area. Signs shall be clean and visible at all times. Where traffic can not be effectively self-regulated, at least one flagger shall be used at each intersection within traffic control area.
- An optional C29(CA) sign may be placed below the C9A(CA) sign.
- Either traffic cones or barricades shall be placed on the taper. Barricades shall be Type I, II, or III.
- The color of the portable transverse rumble strips shall be black or orange. Use 2 arrays, each array shall consist of 3 rumble strips.
- Portable transverse rumble strips shall not be placed on sharp horizontal or vertical curves nor shall they be placed through pedestrian crossings.
- If the portable transverse rumble strips become out of alignment (skewed) by more than 6 inches, measured from one end to the other, they shall be readjusted to bring the placement back to the original location.
- Portable transverse rumble strips are not required if any one of the following conditions is satisfied:
  - Work duration occupies a location for four hours or less
  - Posted speed limit is below 45 MPH
  - Work is of emergency nature
  - Work zone is in snow or icy weather conditions

**LEGEND**

- TRAFFIC CONE
- ⊥ TEMPORARY TRAFFIC CONTROL SIGN
- ⚡ PORTABLE FLASHING BEACON
- 🚧 FLAGGER


**SIGN PANEL SIZE (Min)**

A	48" x 48"
B	30" x 30"
C	36" x 18"
D	36" x 42"
E	20" x 7"

STATE OF CALIFORNIA  
 DEPARTMENT OF TRANSPORTATION  
**TRAFFIC CONTROL SYSTEM  
 FOR LANE CLOSURE ON  
 TWO LANE CONVENTIONAL  
 HIGHWAYS**  
 NO SCALE  
 RSP T13 DATED OCTOBER 17, 2014 SUPERSEDES RSP T13 DATED JULY 18, 2014  
 AND RSP T13 DATED APRIL 19, 2013 AND STANDARD PLAN T13 DATED  
 MAY 20, 2011 - PAGE 241 OF THE STANDARD PLANS BOOK DATED 2010.

2010 REVISED STANDARD PLAN RSP T13

TO ACCOMPANY PLANS DATED 12-8-14

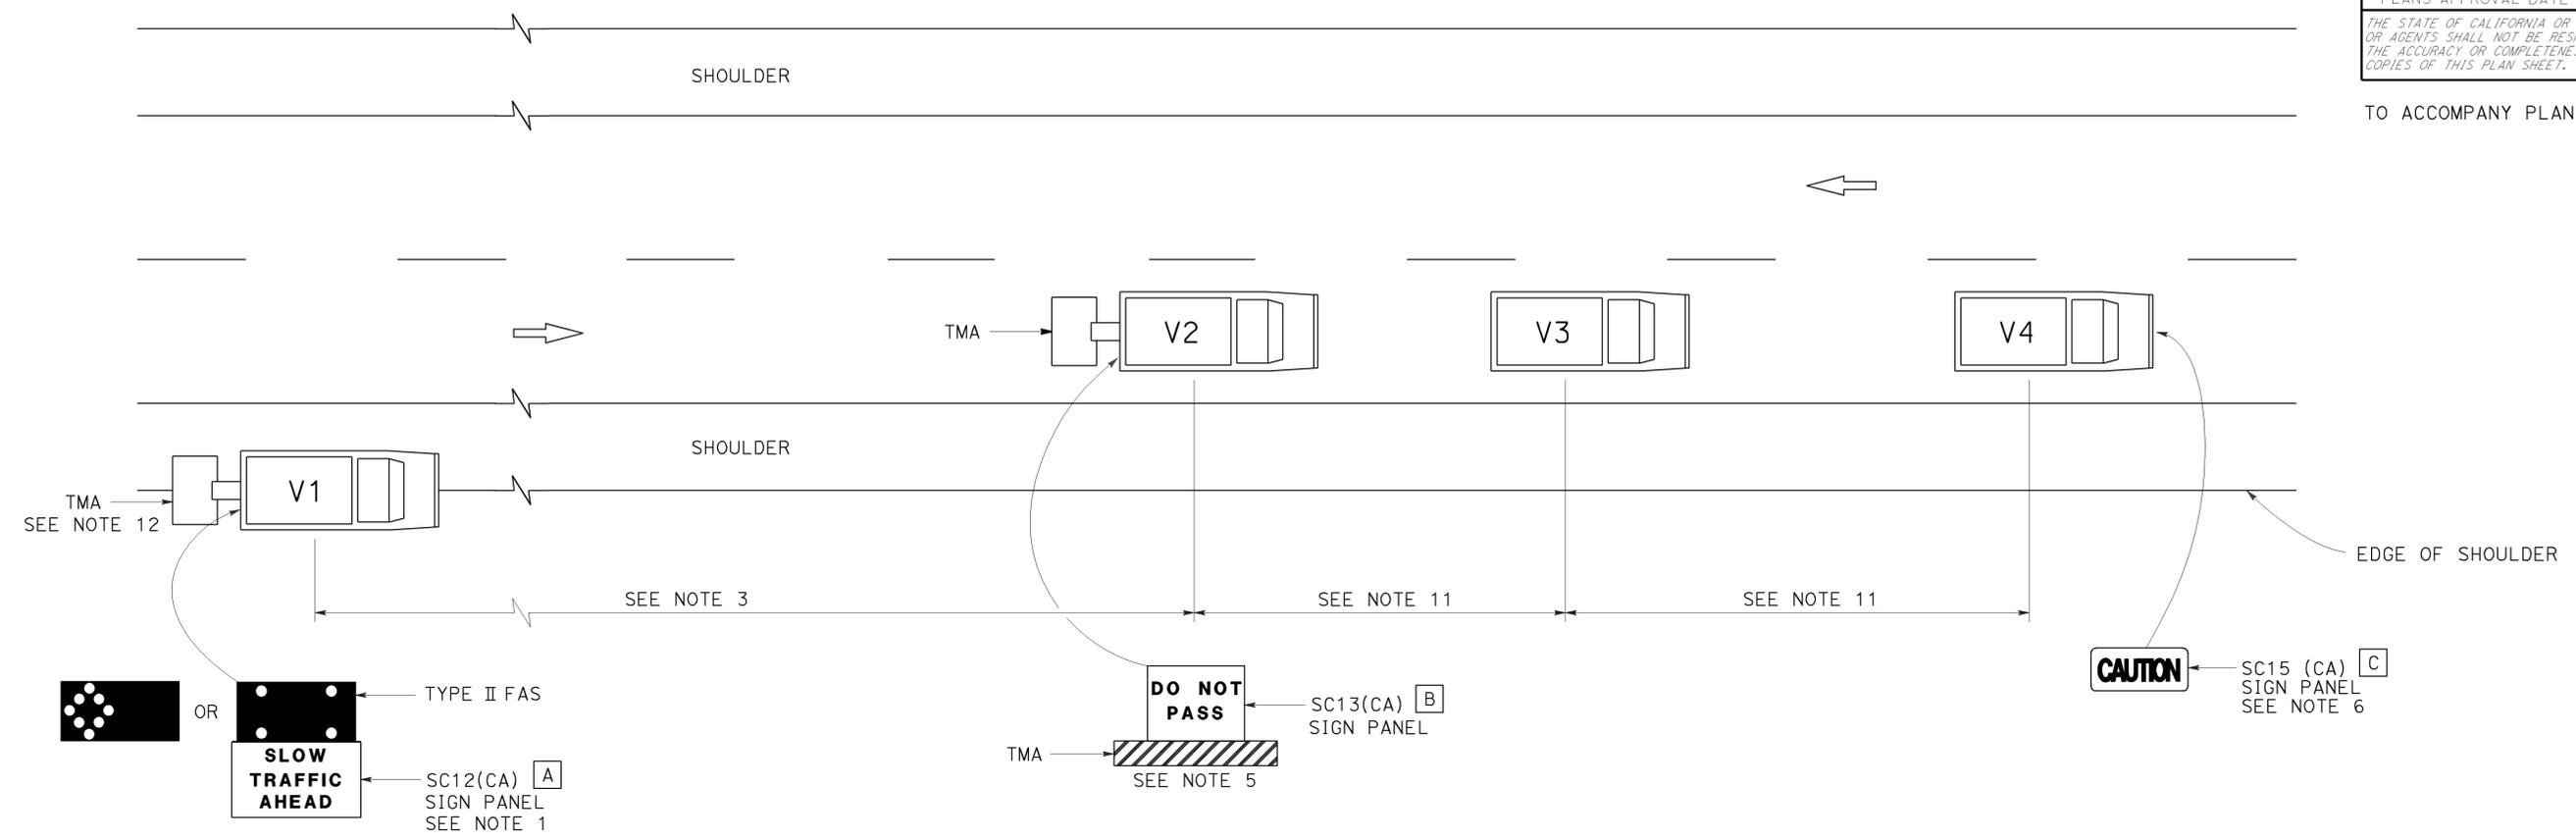

**NOTES:**

1. Either a changeable message sign or a SC12(CA) "SLOW TRAFFIC AHEAD" sign shall be mounted on the rear of sign vehicle V1. The changeable message sign shall be sequenced to show the "CAUTION" message first, follow by the "SLOW TRAFFIC AHEAD" message. A Type II flashing arrow sign may be used with the SC12(CA) sign panel.
2. Sign vehicle V1 should be positioned where highly visible when shoulders are not available.
3. If traffic queues develop, sign vehicle V1 should be positioned upstream from the end of queue.
4. Vehicle-mounted sign panels shall have Type III or above retroreflective sheeting, black on white, or black on fluorescent orange, with 6" minimum series D letters per Caltrans sign specifications.
5. Shadow vehicle shall be equipped with a truck-mounted attenuator. The sign panel shown shall be mounted on the rear of shadow vehicle V2. The message "LANE CLOSED" may be used in place of the "DO NOT PASS" message.
6. The sign panel shown shall be mounted on the front of sign vehicle V4, facing opposing traffic.
7. All vehicles shall be equipped with flashing or rotating amber lights.
8. Sign vehicle V4 will not be required when the work and vehicles V2 and V3 are 2' or more from the centerline of the highway during the work or application operations.
9. All vehicles used for lane closures shall be equipped with two-way radios and the vehicle operators shall maintain communication during the work or application operation.
10. This plan shall not be used where workers would be on foot in the work area. Use a stationary type lane closure (Revised Standard Plan T13) for this condition.
11. Minimize spacing between vehicles V2 and V3 and vehicles V3 and V4 to deter road users from driving in between them.
12. If sign vehicle V1 encroaches into the traffic lane due to insufficient shoulder width, sign vehicle V1 shall be equipped with a truck-mounted attenuator. Sign vehicle V1 shall stay as close to the edge of shoulder as practicable.

**LEGEND**

- V1 SIGN VEHICLE
- V2 SHADOW VEHICLE
- V3 WORK/APPLICATION VEHICLE
- V4 SIGN VEHICLE
- TMA TRUCK-MOUNTED ATTENUATOR
-  FLASHING ARROW SIGN (FAS) IN FLASHING CAUTION MODE
-  FLASHING ARROW SIGN (FAS) IN ALTERNATING DIAMOND CAUTION

**SIGN PANEL SIZE (Min)**

- A** 72" x 42"
- B** 54" x 42"
- C** 54" x 24"

STATE OF CALIFORNIA  
 DEPARTMENT OF TRANSPORTATION  
**TRAFFIC CONTROL SYSTEM  
 FOR MOVING LANE CLOSURE  
 ON TWO LANE HIGHWAYS**  
 NO SCALE

RSP T17 DATED APRIL 19, 2013 SUPERSEDES STANDARD PLAN T17  
 DATED MAY 20, 2011 - PAGE 245 OF THE STANDARD PLANS BOOK DATED 2010.

**REVISED STANDARD PLAN RSP T17**

2010 REVISED STANDARD PLAN RSP T17

**LEGEND:**

<b>AB</b>	ABANDON. IF APPLIED TO CONDUIT, REMOVE CONDUCTORS
<b>BC</b>	INSTALL PULL BOX IN EXISTING CONDUIT RUN
<b>BP</b>	PEDESTRIAN BARRICADE, TYPE AS INDICATED ON PLAN
<b>CB</b>	INSTALL CONDUIT INTO EXISTING PULL BOX
<b>CC</b>	CONNECT NEW AND EXISTING CONDUIT. REMOVE EXISTING CONDUCTORS AND INSTALL CONDUCTORS AS INDICATED
<b>CF</b>	CONDUIT TO REMAIN FOR FUTURE USE. REMOVE CONDUCTORS. INSTALL PULL TAPE
<b>DH</b>	DETECTOR HANDHOLE
<b>FA</b>	FOUNDATION TO BE ABANDONED
<b>IS</b>	INSTALL SIGN ON SIGNAL MAST ARM
<b>NS</b>	NO SLIP BASE ON STANDARD
<b>PEC</b>	PHOTOELECTRIC CONTROL
<b>PEU</b>	PHOTOELECTRIC UNIT
<b>RC</b>	EQUIPMENT OR MATERIAL TO BE REMOVED AND BECOME THE PROPERTY OF THE CONTRACTOR
<b>RE</b>	REMOVE ELECTROLIER, FUSES AND BALLAST. TAPE ENDS OF CONDUCTORS
<b>RL</b>	RELOCATE EQUIPMENT
<b>RR</b>	REMOVE AND REUSE EQUIPMENT
<b>RS</b>	REMOVE AND SALVAGE EQUIPMENT
<b>SC</b>	SPLICE NEW TO EXISTING CONDUCTORS
<b>SD</b>	SERVICE DISCONNECT
<b>TSP</b>	TELEPHONE SERVICE POINT

**ABBREVIATIONS**

APS	ACCESSIBLE PEDESTRIAN SIGNAL	M/M	MULTIPLE TO MULTIPLE TRANSFORMER
BBS	BATTERY BACKUP SYSTEM	Mtg	MOUNTING
BC	BOLT CIRCLE	MV	MERCURY VAPOR LIGHTING FIXTURE
BPB	BICYCLE PUSH BUTTON	MVDS	MICROWAVE VEHICLE DETECTION SYSTEM
C	CONDUIT	N	NEUTRAL (GROUNDED CONDUCTOR)
CB	CIRCUIT BREAKER	NB	NEUTRAL BUS
CCTV	CLOSED CIRCUIT TELEVISION	NC	NORMALLY CLOSE
Ck+	CIRCUIT	NO	NORMALLY OPEN
CMS	CHANGEABLE MESSAGE SIGN	P	CIRCUIT BREAKER'S POLE
Ctid	CALTRANS IDENTIFICATION	PB	PULL BOX
Comm	COMMUNICATION	PBA	PUSH BUTTON ASSEMBLY
DLC	LOOP DETECTOR LEAD-IN CABLE	PEC	PHOTOELECTRIC CONTROL
EMS	EXTINGUISHABLE MESSAGE SIGN	Ped	PEDESTRIAN
EVUC	EMERGENCY VEHICLE UNIT CABLE	PEU	PHOTOELECTRIC UNIT
EVUD	EMERGENCY VEHICLE UNIT DETECTOR	PT	CONDUIT WITH PULL TAPE
FB	FLASHING BEACON	RE	RELOCATED EQUIPMENT
FBCA	FLASHING BEACON CONTROL ASSEMBLY	RM	RAMP METERING
FBS	FLASHING BEACON WITH SLIP BASE	RWIS	ROADSIDE WEATHER INFORMATION SYSTEM
FO	FIBER OPTIC	SB	SLIP BASE
G	EQUIPMENT GROUNDING CONDUCTOR	SIC	SIGNAL INTERCONNECT CABLE
GB	GROUND BUS	Sig	SIGNAL
GFCI	GROUND FAULT CIRCUIT INTERRUPTER	SMA	SIGNAL MAST ARM
HAR	HIGHWAY ADVISORY RADIO	SNS	STREET NAME SIGN
Hex	HEXAGONAL	SP	SERVICE POINT
HPS	HIGH PRESSURE SODIUM	TDC	TELEPHONE DEMARCATION CABINET
IISNS	INTERNALLY ILLUMINATED STREET NAME SIGN	TMS	TRAFFIC MONITORING STATION
ISL	INDUCTION SIGN LIGHTING	TOS	TRAFFIC OPERATIONS SYSTEM
LED	LIGHT EMITTING DIODE	Veh	VEHICLE
LMA	LUMINAIRE MAST ARM	VIVDS	VIDEO IMAGE VEHICLE DETECTION SYSTEM
LPS	LOW PRESSURE SODIUM	WIM	WEIGH-IN-MOTION
Ltg	LIGHTING	Xfmr	TRANSFORMER
Lum	LUMINAIRE		
M	METERED		
MAT	MAST ARM MOUNTING TOP ATTACHMENT		
MAS	MAST ARM MOUNTING SIDE ATTACHMENT		

Dist	COUNTY	ROUTE	POST MILES TOTAL PROJECT	SHEET No.	TOTAL SHEETS
06	Ker	58	28.2/31.5	12	16

*Theresa Gabriel*  
REGISTERED ELECTRICAL ENGINEER

July 19, 2013  
PLANS APPROVAL DATE

Theresa Aziz Gabriel  
No. E15129  
Exp. 6-30-14  
ELECTRICAL  
STATE OF CALIFORNIA

THE STATE OF CALIFORNIA OR ITS OFFICERS OR AGENTS SHALL NOT BE RESPONSIBLE FOR THE ACCURACY OR COMPLETENESS OF SCANNED COPIES OF THIS PLAN SHEET.

TO ACCOMPANY PLANS DATED 12-8-14

**SOFFIT AND WALL MOUNTED LUMINAIRES**

- PENDANT, 70 W HPS UNLESS OTHERWISE SPECIFIED
- FLUSH, 70 W HPS UNLESS OTHERWISE SPECIFIED
- WALL SURFACE, 70 W HPS UNLESS OTHERWISE SPECIFIED
- EXISTING SOFFIT OR WALL LUMINAIRE TO REMAIN UNMODIFIED
- EXISTING SOFFIT OR WALL LUMINAIRE TO BE MODIFIED AS SPECIFIED

**NOTE:**  
Arrow indicates "street side" of luminaire.

COMMONLY USED SYMBOLS FOR UNITED STATES CUSTOMARY UNITS OF MEASUREMENT:

SYMBOL USED	DEFINITIONS
$\Omega$	OHMS
min	MINUTE
s	SECOND
bps	BITS PER SECOND
Bps	BYTES PER SECOND
A	AMPERE
V	VOLT
V(dc)	VOLT (DIRECT CURRENT)
V(ac)	VOLT (ALTERNATING CURRENT)
FC	FOOT - CANDLE
W	WATTS
VA	VOLT-AMPERE
M	MEGA
k	KILO
m	MILLI
$\mu$	MICRO
P	PICO
Hz	HERTZ

**MISCELLANEOUS ELECTROLIERS**

NEW	EXISTING	
		LUMINAIRE ON WOOD POLE
		NON-STANDARD ELECTROLIER (SEE PROJECT NOTES OR PROJECT PLANS)
		CITY ELECTROLIER
		ELECTROLIER FOUNDATION (FUTURE INSTALLATION)

**NOTES:**

- HPS luminaires shall be 310 W HPS when installed on Type 21, 21D, 30, 31 and 32 Standards, unless otherwise specified. HPS luminaires shall be 200 W when installed on other type standards or poles, unless otherwise specified.
- LED luminaires shall be 235 W when installed on Type 21, 21D, 30, 31 and 32 Standards, unless otherwise specified. LED luminaires shall be 165 W when installed on other type standards or poles, unless otherwise specified.
- Luminaires shall be the cutoff type, ANSI Type III medium cutoff lighting distribution, unless otherwise specified.

**STANDARD ELECTROLIER**

NEW	EXISTING	STANDARD TYPE
		15
		15D
		15 STRUCTURE
		15D STRUCTURE
		21
		21D
		21 STRUCTURE
		21D STRUCTURE
		30
		31
		32

STATE OF CALIFORNIA  
DEPARTMENT OF TRANSPORTATION

**ELECTRICAL SYSTEMS (LEGEND AND ABBREVIATIONS)**

NO SCALE

RSP ES-1A DATED JULY 19, 2013 SUPERSEDES STANDARD PLAN ES-1A DATED MAY 20, 2011 - PAGE 425 OF THE STANDARD PLANS BOOK DATED 2010.

**REVISED STANDARD PLAN RSP ES-1A**

2010 REVISED STANDARD PLAN RSP ES-1A

Dist	COUNTY	ROUTE	POST MILES TOTAL PROJECT	SHEET No.	TOTAL SHEETS
06	Ker	58	28.2/31.5	13	16

*Theresa Gabriel*  
REGISTERED ELECTRICAL ENGINEER

July 19, 2013  
PLANS APPROVAL DATE

Theresa Aziz Gabriel  
No. E15129  
Exp. 6-30-14  
ELECTRICAL  
STATE OF CALIFORNIA

THE STATE OF CALIFORNIA OR ITS OFFICERS OR AGENTS SHALL NOT BE RESPONSIBLE FOR THE ACCURACY OR COMPLETENESS OF SCANNED COPIES OF THIS PLAN SHEET.

TO ACCOMPANY PLANS DATED 12-8-14

 
**CONDUIT**

NEW	EXISTING	
---	---	LIGHTING CONDUIT, UNLESS OTHERWISE INDICATED OR NOTED
---	---	TRAFFIC SIGNAL CONDUIT
---C---	---c---	COMMUNICATION CONDUIT
---T---	---t---	TELEPHONE CONDUIT
---F---	---f---	FIRE ALARM CONDUIT
---FO---	---fo---	FIBER OPTIC CONDUIT
---	---	CONDUIT TERMINATION
		CONDUIT RISER ATTACHED TO THE STRUCTURE OR SERVICE POLE

**SERVICE EQUIPMENT**

NEW	EXISTING	
---OH---	---oh---	OVERHEAD LINES
		WOOD POLE, "U" INDICATES UTILITY OWNED
		POLE GUY WITH ANCHOR
		UTILITY TRANSFORMER - GROUND MOUNTED
		SERVICE EQUIPMENT ENCLOSURE TYPE. DOOR INDICATES FRONT OF ENCLOSURE
		TELEPHONE DEMARCATION CABINET

**POLE-MOUNTED SERVICE DESIGNATION**



**FLASHING BEACON**

NEW	EXISTING	
		FLASHING BEACON (ONE VEHICLE SIGNAL HEAD WITH BACKPLATE AND VISOR) "R" INDICATES RED INDICATION, "Y" INDICATES YELLOW INDICATION
		FLASHING BEACON WITH TYPE 15-FBS STANDARD AND A SIGN.
		FLASHING BEACON WITH TYPES 9, 9A OR 9B SIGN UNLESS OTHERWISE SPECIFIED OR INDICATED

**SIGNAL EQUIPMENT**

NEW	EXISTING	
		PEDESTRIAN SIGNAL HEAD "C" INDICATES COUNTDOWN PEDESTRIAN HEAD
		PUSH BUTTON ASSEMBLY POST
		PEDESTRIAN BARRICADE
		VEHICLE SIGNAL HEAD (WITH BACKPLATE AND 3-SECTIONS: RED, YELLOW AND GREEN)
		VEHICLE SIGNAL HEAD WITH ANGLE VISOR
		MODIFICATIONS OF BASIC SYMBOL: "L" INDICATES ALL NON-ARROW SECTIONS LOUVERED "LG" INDICATES LOUVERED GREEN SECTION ONLY "PV" INDICATES ALL 12" SECTIONS PROGRAMMED VISIBILITY "8" INDICATES ALL 8" SECTIONS (ONLY WHEN SPECIFIED)
		VEHICLE SIGNAL HEAD CONSISTING OF RED, YELLOW AND GREEN LEFT ARROW SECTIONS
		VEHICLE SIGNAL HEAD CONSISTING OF RED AND YELLOW SECTIONS WITH AN UP GREEN ARROW SECTION
		VEHICLE SIGNAL HEAD (5 SECTION) CONSISTING OF RED, YELLOW AND GREEN SECTIONS WITH YELLOW AND GREEN RIGHT ARROW SECTIONS
		TYPE 15TS STANDARD WITH VEHICLE SIGNAL HEAD AND LUMINAIRE
		TYPE 21TS STANDARD WITH VEHICLE SIGNAL HEAD AND LUMINAIRE
		STANDARD WITH LUMINAIRE AND SIGNAL MAST ARMS AND ATTACHED VEHICLE SIGNAL HEADS
		TYPE 1 STANDARD WITH ATTACHED VEHICLE SIGNAL HEADS
		STANDARD WITH A SIGNAL MAST ARM, ATTACHED VEHICLE SIGNAL HEADS AND INTERNALLY ILLUMINATED STREET NAME SIGN
		CONTROLLER ASSEMBLY. DOOR INDICATES FRONT OF CABINET

**SIGNAL EQUIPMENT Cont**

NEW	EXISTING	
		GUARD POST
		TYPE 1 STANDARD WITH RAMP METERING SIGN
		OPTICAL DETECTOR FOR THE EMERGENCY VEHICLE DETECTION SYSTEM

**NOTES:**

1. All signal sections shall be 12" unless shown otherwise.
2. Signal heads shall be provided with backplates unless shown otherwise.

**ILLUMINATED OVERHEAD SIGN**

NEW	EXISTING	
		SINGLE POST, SINGLE ILLUMINATED SIGN, BALANCED BUTTERFLY
		SINGLE POST, DOUBLE ILLUMINATED SIGN, BALANCED BUTTERFLY
		SINGLE POST, SINGLE ILLUMINATED SIGN, FULL CANTILEVER
		DOUBLE POST, SINGLE ILLUMINATED SIGN
		SINGLE ILLUMINATED SIGN MOUNTED ON STRUCTURE
		DOUBLE POST, SINGLE ILLUMINATED SIGN WITH ELECTROLIER

STATE OF CALIFORNIA  
DEPARTMENT OF TRANSPORTATION

**ELECTRICAL SYSTEMS  
(LEGEND AND ABBREVIATIONS)**

NO SCALE

RSP ES-1B DATED JULY 19, 2013 SUPERSEDES STANDARD PLAN ES-1B DATED MAY 20, 2011 - PAGE 426 OF THE STANDARD PLANS BOOK DATED 2010.


**REVISED STANDARD PLAN RSP ES-1B**

2010 REVISED STANDARD PLAN RSP ES-1B


TO ACCOMPANY PLANS DATED 12-8-14

### EQUIPMENT IDENTIFICATION


#### ILLUMINATED SIGN IDENTIFICATION NUMBER:

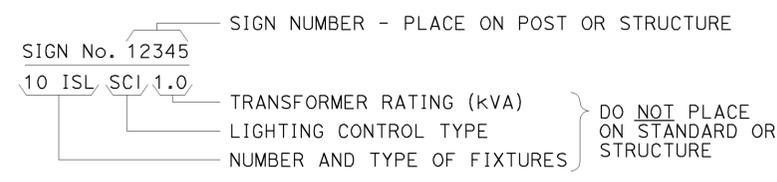


#### ELECTROLIER OR EQUIPMENT IDENTIFICATION NUMBER:

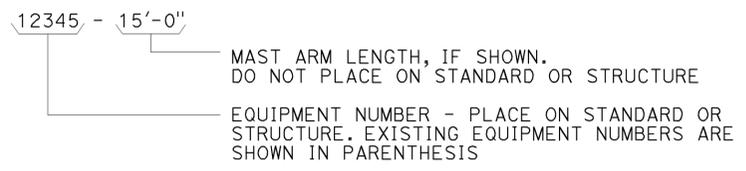


#### CONDUIT AND CONDUCTOR IDENTIFICATION:

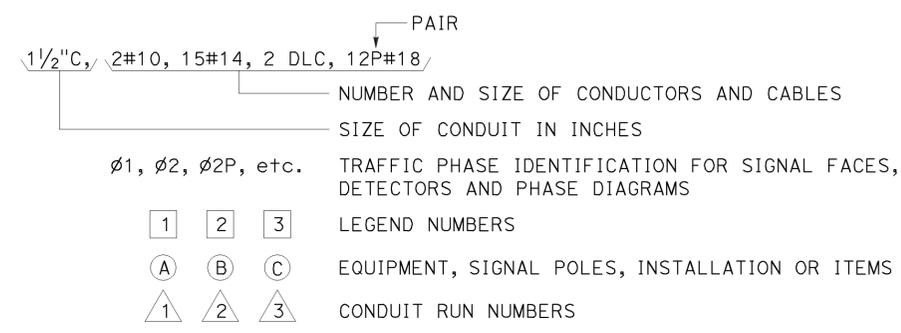


#### SIGNAL AND LIGHTING STANDARD (TYPICAL DESIGNATION):

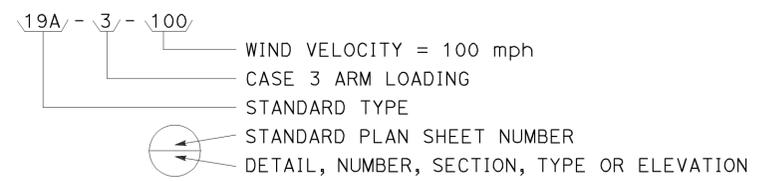


### MISCELLANEOUS EQUIPMENT

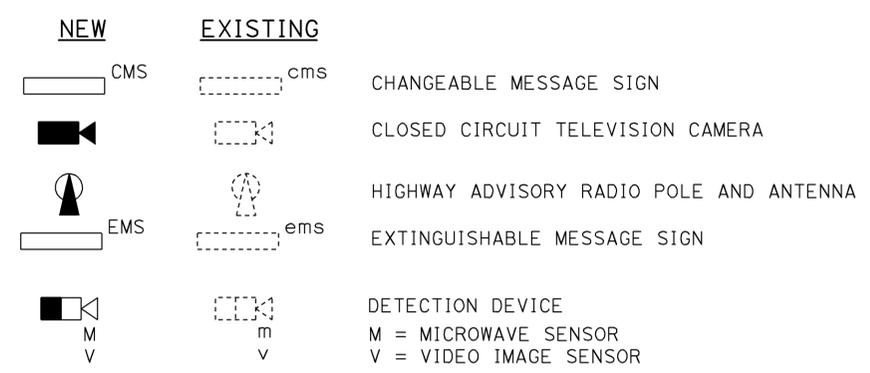



### WIRING DIAGRAM LEGEND

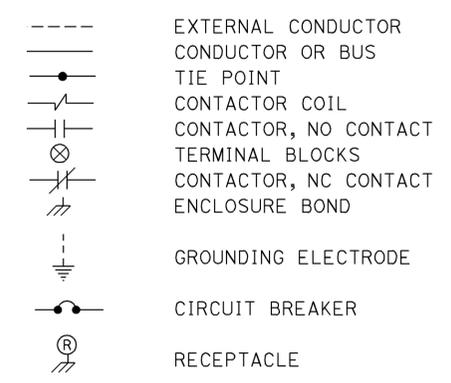

### PULL BOXES

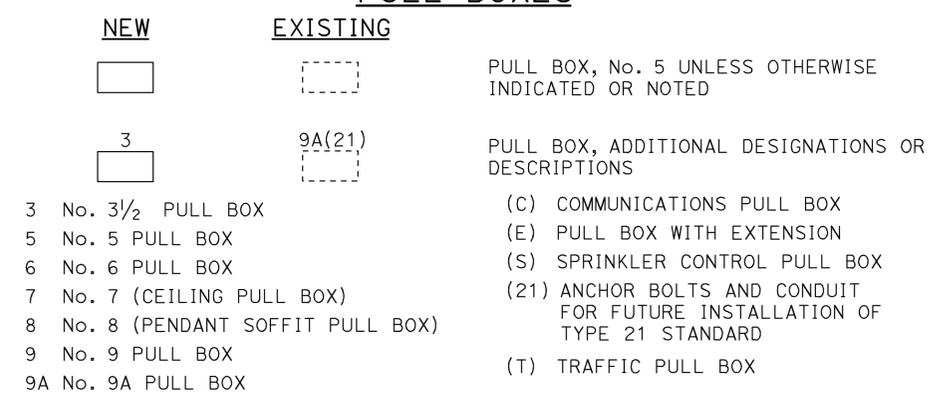

### VEHICLE DETECTORS

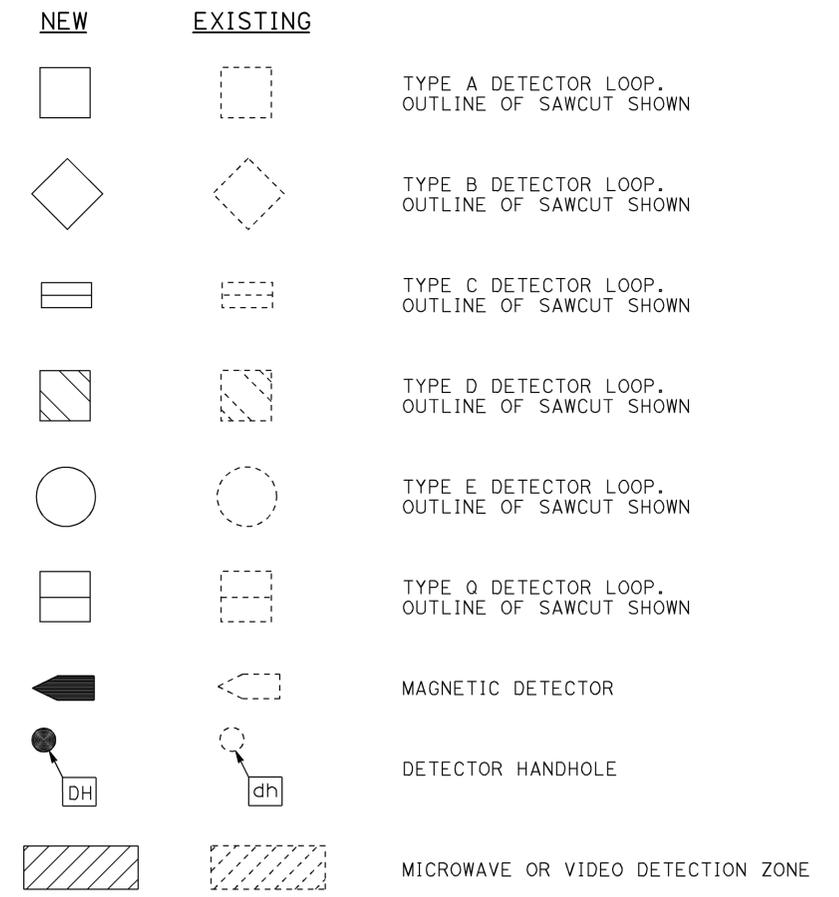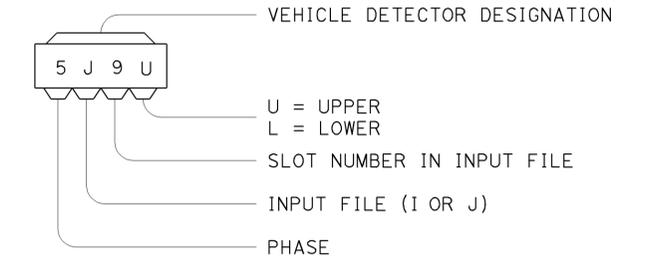

STATE OF CALIFORNIA  
DEPARTMENT OF TRANSPORTATION

## ELECTRICAL SYSTEMS (LEGEND AND ABBREVIATIONS)

NO SCALE

RSP ES-1C DATED JULY 19, 2013 SUPERSEDES STANDARD PLAN ES-1C DATED MAY 20, 2011 - PAGE 427 OF THE STANDARD PLANS BOOK DATED 2010.


2010 REVISED STANDARD PLAN RSP ES-1C

Dist	COUNTY	ROUTE	POST MILES TOTAL PROJECT	SHEET No.	TOTAL SHEETS
06	Ker	58	28.2/31.5	15	16


*Theresa Gabriel*  
 REGISTERED ELECTRICAL ENGINEER  
 July 19, 2013  
 PLANS APPROVAL DATE  
THE STATE OF CALIFORNIA OR ITS OFFICERS OR AGENTS SHALL NOT BE RESPONSIBLE FOR THE ACCURACY OR COMPLETENESS OF SCANNED COPIES OF THIS PLAN SHEET.

TO ACCOMPANY PLANS DATED 12-8-14


2010 REVISED STANDARD PLAN RSP ES-5B

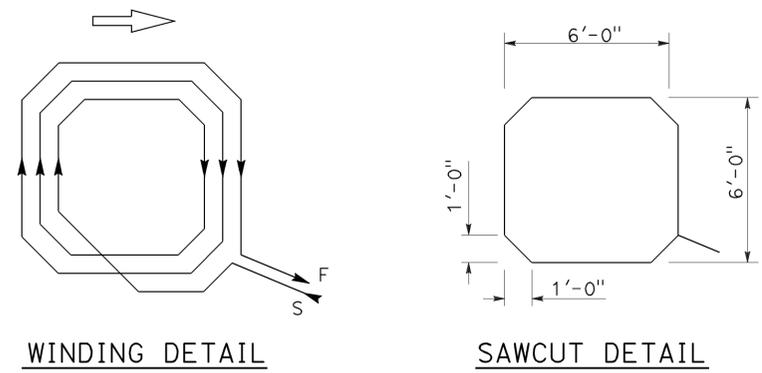


WINDING DETAIL  
SAWCUT DETAIL  
**TYPE A LOOP DETECTOR CONFIGURATION**

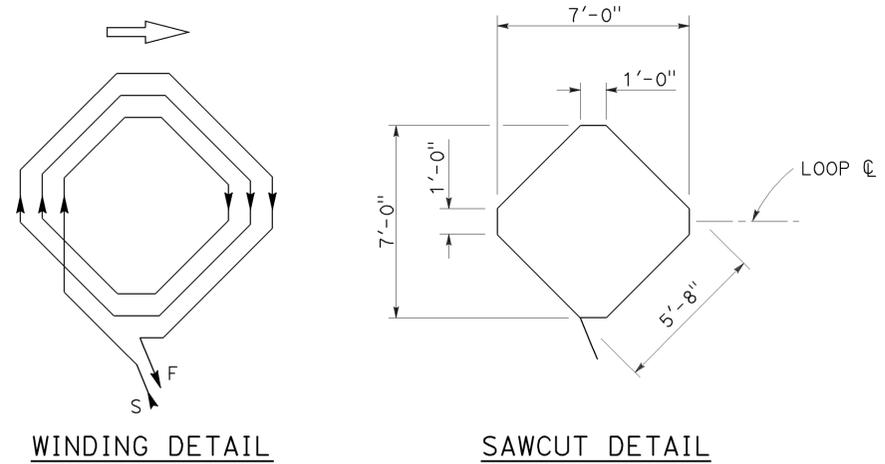


WINDING DETAIL  
SAWCUT DETAIL  
**TYPE B LOOP DETECTOR CONFIGURATION**

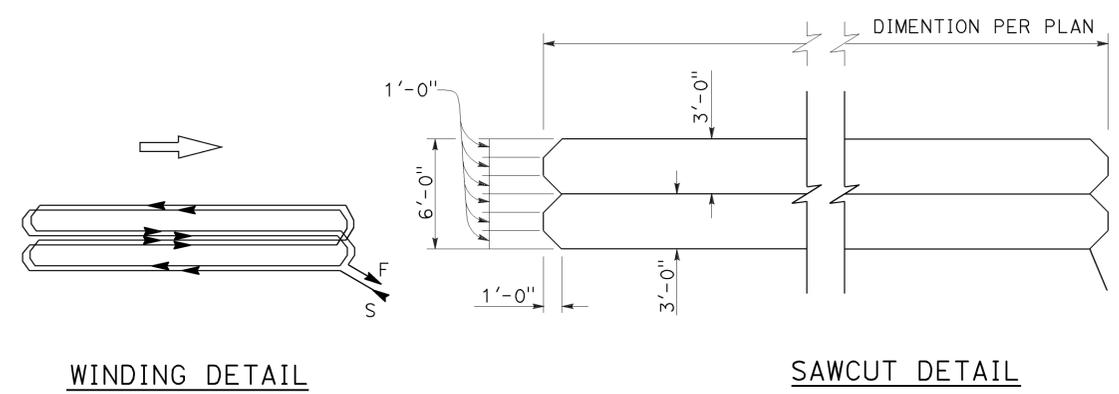


WINDING DETAIL  
SAWCUT DETAIL  
**TYPE C LOOP DETECTOR CONFIGURATION**

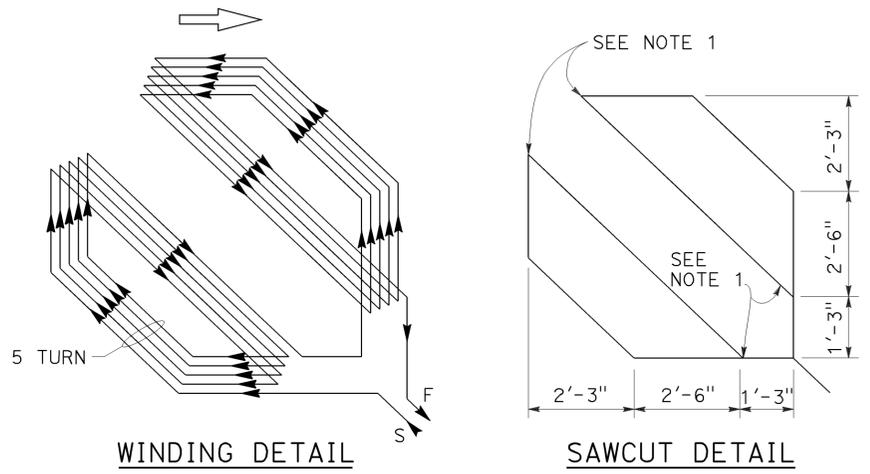


WINDING DETAIL  
SAWCUT DETAIL  
**TYPE D LOOP DETECTOR CONFIGURATION**

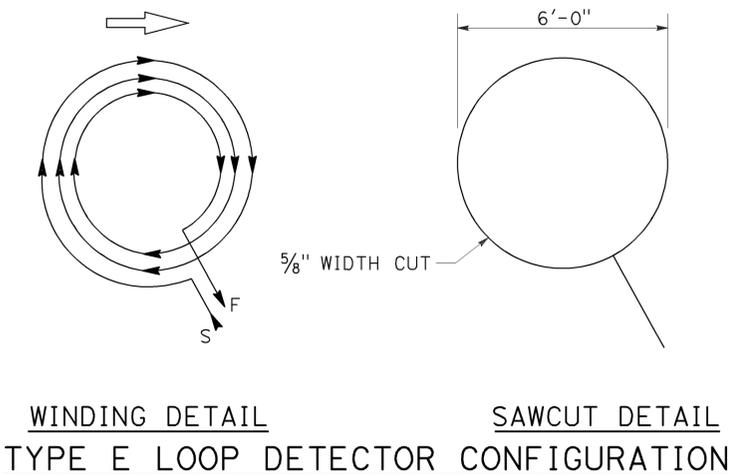

WINDING DETAIL  
SAWCUT DETAIL  
**TYPE E LOOP DETECTOR CONFIGURATION**

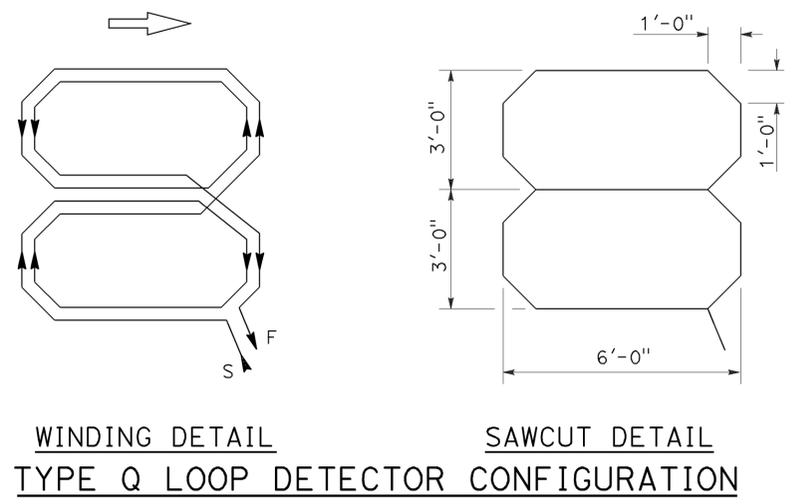

WINDING DETAIL  
SAWCUT DETAIL  
**TYPE Q LOOP DETECTOR CONFIGURATION**

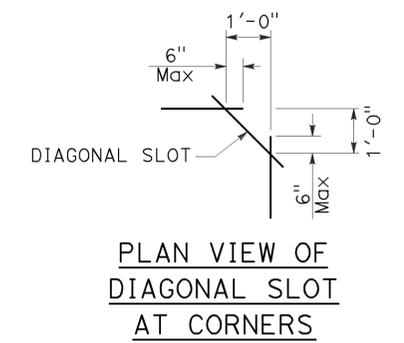

**PLAN VIEW OF  
DIAGONAL SLOT  
AT CORNERS**

- NOTES:**
1. Round corners of acute angle sawcuts to prevent damage to conductors.
  2. Typical distance separating loops from edge to edge is 10' for Type A, B, D and E installation in single lane.

STATE OF CALIFORNIA  
DEPARTMENT OF TRANSPORTATION  
**ELECTRICAL SYSTEMS  
(DETECTORS)**  
NO SCALE

RSP ES-5B DATED JULY 19, 2013 SUPERSEDES STANDARD PLAN ES-5B  
DATED MAY 20, 2011 - PAGE 449 OF THE STANDARD PLANS BOOK DATED 2010.


**REVISED STANDARD PLAN RSP ES-5B**

DIST	COUNTY	ROUTE	POST MILES TOTAL PROJECT	SHEET NO.	TOTAL SHEETS
06	Ker	58	28.2/31.5	16	16

*Theresa Gabriel*  
 REGISTERED ELECTRICAL ENGINEER  
 July 19, 2013  
 PLANS APPROVAL DATE

THE STATE OF CALIFORNIA OR ITS OFFICERS OR AGENTS SHALL NOT BE RESPONSIBLE FOR THE ACCURACY OR COMPLETENESS OF SCANNED COPIES OF THIS PLAN SHEET.

TO ACCOMPANY PLANS DATED 12-8-14

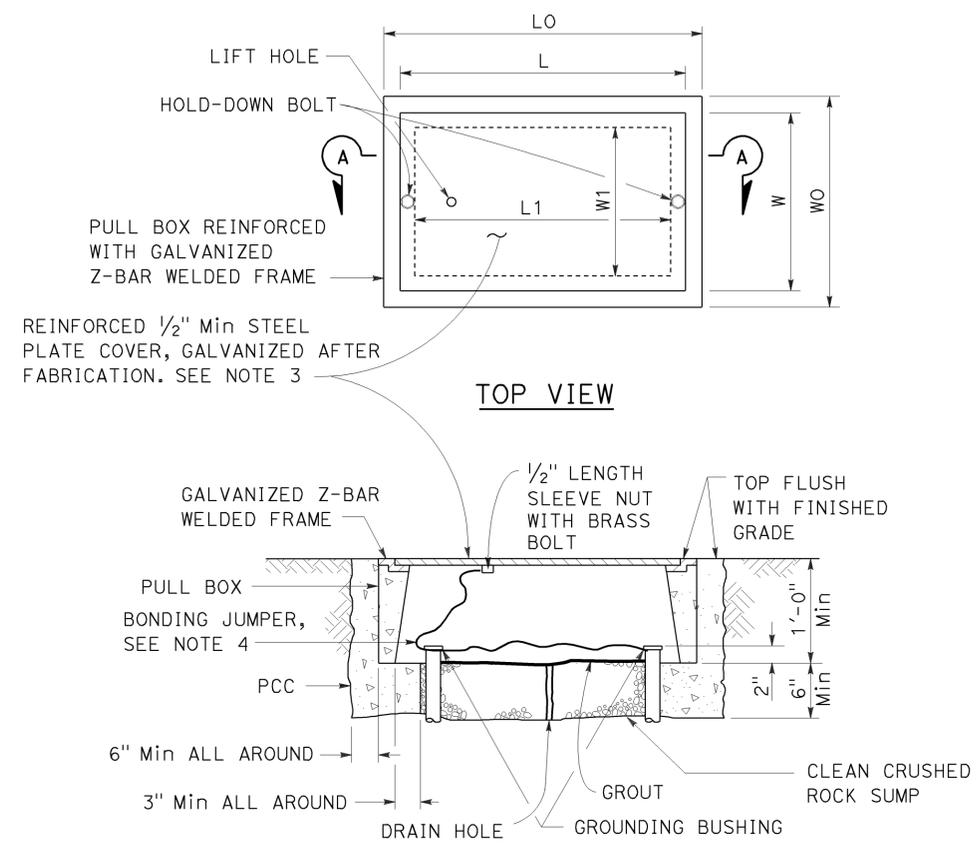

**SECTION A-A**  
**No. 3 1/2(T), No. 5(T) AND**  
**No. 6(T) TRAFFIC PULL BOX**

**NOTES:**

- Traffic pull box shall be provided with steel cover and special concrete footing. Steel cover shall have embossed non-skid pattern.
- Steel reinforcing shall be as regularly used in the standard products of the respective manufacturer.
- Pull box covers shall be marked as follows: "SERVICE" Service circuits between service point and service disconnect; "SPRINKLER-CONTROL" Sprinkler control circuits, 50 V or less; "CALTRANS" On all pull boxes, except pull boxes marked "SPRINKLER-CONTROL"; and "TELEPHONE" Telephone service.
  - No. 3 1/2(T) pull box.
    - "SIGNAL" - Traffic signal circuits with or without lighting or sign lighting circuits.
    - "LIGHTING" - Lighting or sign lighting circuits where voltage is under 600 V.
  - No. 5(T) or 6(T) pull box.
    - "TRAFFIC SIGNAL" - Traffic signal circuits with or without lighting or sign lighting circuits.
    - "LIGHTING" - Lighting or sign lighting circuits where voltage is under 600 V.
    - "LIGHTING-HIGH VOLTAGE" - Lighting or sign lighting circuits where voltage is above 600 V.
    - "IRRIGATION" - Circuits to irrigation controller 120 V or more.
    - "RAMP METER" - Ramp meter circuits.
    - "COUNT STATION" - Count or speed monitor circuits.
    - "COMMUNICATION" - Communication circuits.
    - "TOS COMMUNICATIONS" - TOS communications line.
    - "TOS POWER" - TOS power.
    - "TDC POWER" - Telephone demarcation cabinet power.
    - "CCTV" - Closed circuit television circuits.
    - "TMS" - Traffic monitoring station circuits.
    - "CMS" - Changeable message sign circuits.
    - "HAR" - Highway advisory radio circuits.
    - "BOOSTER PUMP" - Booster pump circuit.
- Bonding jumper for metal covers shall be 3' long, minimum.
- The nominal dimensions of the opening in which the cover sets shall be the same as the cover dimensions except the length and width dimensions shall be 1/8" greater.
- Covers and boxes shall be interchangeable with California standard male and female gages. When interchanged with a standard male or female gage, the top surfaces shall be flush within 1/8".

DIMENSION TABLE											
PULL BOX	PULL BOX						COVER				
	MINIMUM * THICKNESS	MINIMUM DEPTH BOX AND EXTENSION	W0	L0	L1	W1	L **	W **	R	EDGE THICKNESS	EDGE TAPER
No. 3 1/2(T)	1 1/2"	1'-0"	1'-5"± 1"	1'-8 3/8"±	1'-2 1/2"±	10 5/8"± 1"	1'-8"±	1'-1 3/4"±	0"	1/2"	NONE
No. 5(T)	1 3/4"	1'-0"	1'-11 1/2"± 1"	2'-5 1/2"±	1'-7"±	1'-1"± 1"	2'-3"±	1'-4"±	0"	1/2"	NONE
No. 6(T)	2"	1'-0"	2'-6"± 1"	2'-11 1/2"±	1'-11 1/2"±	1'-5"± 1"	2'-9"±	1'-8"±	0"	1/2"	NONE

\* EXCLUDING CONDUIT WEB      \*\* TOP DIMENSION

STATE OF CALIFORNIA  
 DEPARTMENT OF TRANSPORTATION  
**ELECTRICAL SYSTEMS**  
**(TRAFFIC PULL BOX)**  
 NO SCALE

RSP ES-8B DATED JULY 19, 2013 SUPERSEDES RSP ES-8B DATED JANUARY 20, 2012 THAT SUPPLEMENTS THE STANDARD PLANS BOOK DATED 2010.

**REVISED STANDARD PLAN RSP ES-8B**

2010 REVISED STANDARD PLAN RSP ES-8B