


DIST	COUNTY	ROUTE	POST MILES TOTAL PROJECT	SHEET No	TOTAL SHEETS
08	SBd	58	R22.2/R31.1	717A	900
 REGISTERED CIVIL ENGINEER DATE 11/6/13					
5-5-14 PLANS APPROVAL DATE					
<small>The State of California or its officers or agents shall not be responsible for the accuracy or completeness of electronic copies of this plan sheet.</small>					

6

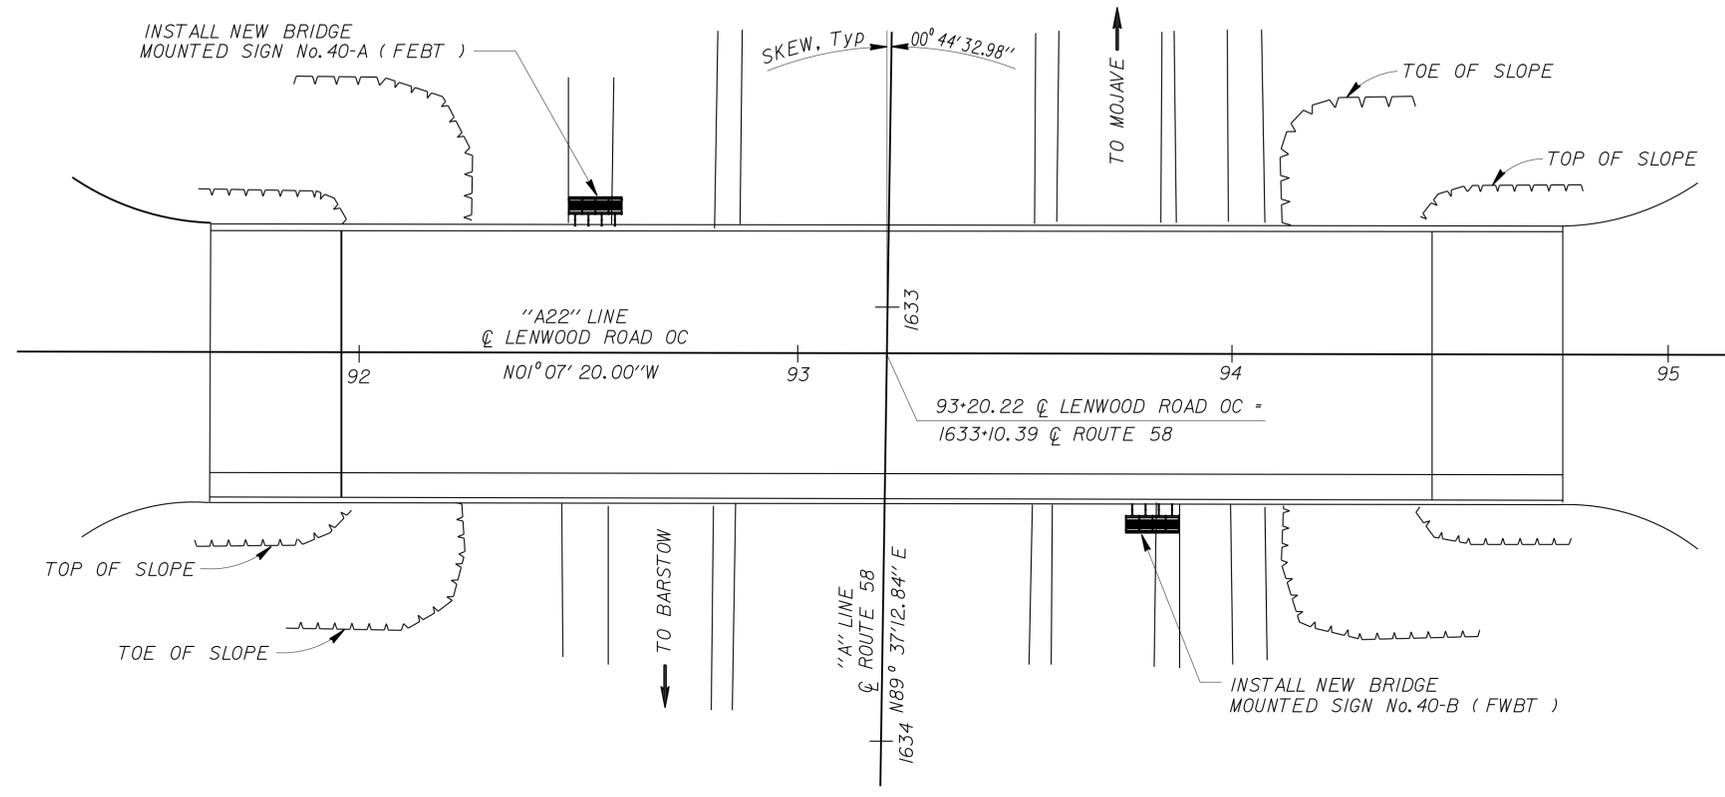


 **LOCATION PLAN**

 - NOTES:**
1. This plan accurate only for the orientation of the bridge mounted signs relative to the bridges.
  2. For sign locations, see "SIGN PLANS".
  3. For sign illumination equipment, see "ELECTRICAL PLANS".

**STANDARD PLANS 2010**  
 AIOA ACRONYMS AND ABBREVIATIONS ( SHEET 1 OF 2 )  
 AIOB ACRONYMS AND ABBREVIATIONS ( SHEET 2 OF 2 )

NOTE:  
 THE CONTRACTOR SHALL VERIFY ALL  
 CONTROLLING FIELD DIMENSIONS  
 BEFORE ORDERING OR FABRICATING  
 ANY MATERIAL.

 **ADDED PER ADDENDUM No. 6 DATED NOVEMBER 5, 2014**




BRANCH CHIEF <b>JEFF WOODY</b>	DESIGN BY <b>JUAN JAUREGUI</b>	CHECKED <b>ARLENA GUTIERREZ</b>	<b>STATE OF CALIFORNIA</b> DEPARTMENT OF TRANSPORTATION	DIVISION OF ENGINEERING SERVICES DESIGN AND TECHNICAL SERVICES <b>SPECIAL DESIGNS BRANCH</b>	BRIDGE NO. 54-1296	<b>LENWOOD ROAD OVERCROSSING</b> <b>BRIDGE MOUNTED SIGN - LOCATION PLAN</b>	<b>SDS-1</b>
	DETAILS BY <b>R. YEE</b>	CHECKED <b>JUAN JAUREGUI</b>			POST MILE R30.4		
	QUANTITIES BY <b>JUAN JAUREGUI</b>	CHECKED <b>ARLENA GUTIERREZ</b>					


USERNAME => s128843 DATE PLOTTED => 05-NOV-2014 TIME PLOTTED => 11:30

DIST	COUNTY	ROUTE	POST MILES TOTAL PROJECT	SHEET No	TOTAL SHEETS
08	SBd	58	R22.2/R31.1	717B	900
REGISTERED CIVIL ENGINEER JUAN J. JAUREGUI JR. No. C63939 Exp. 9/30/14 CIVIL STATE OF CALIFORNIA			11/6/13 DATE	5-5-14 PLANS APPROVAL DATE	
The State of California or its officers or agents shall not be responsible for the accuracy or completeness of electronic copies of this plan sheet.					

6

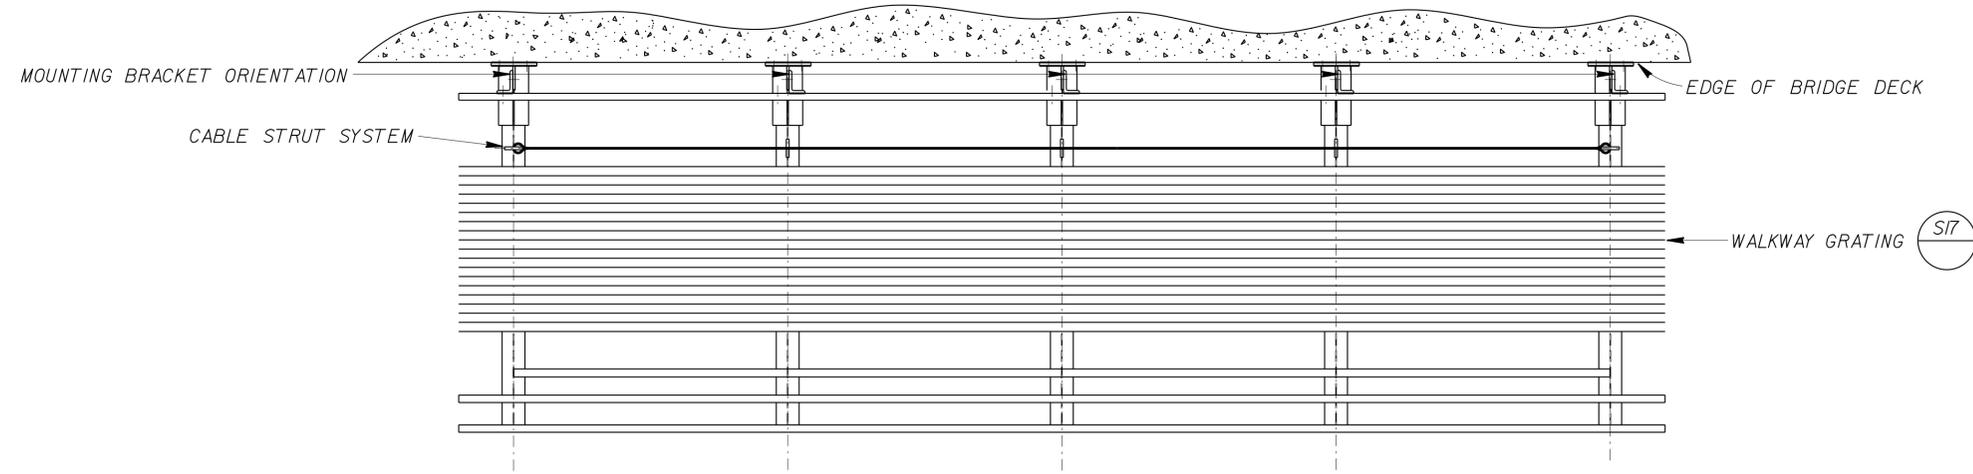


**PLAN VIEW**

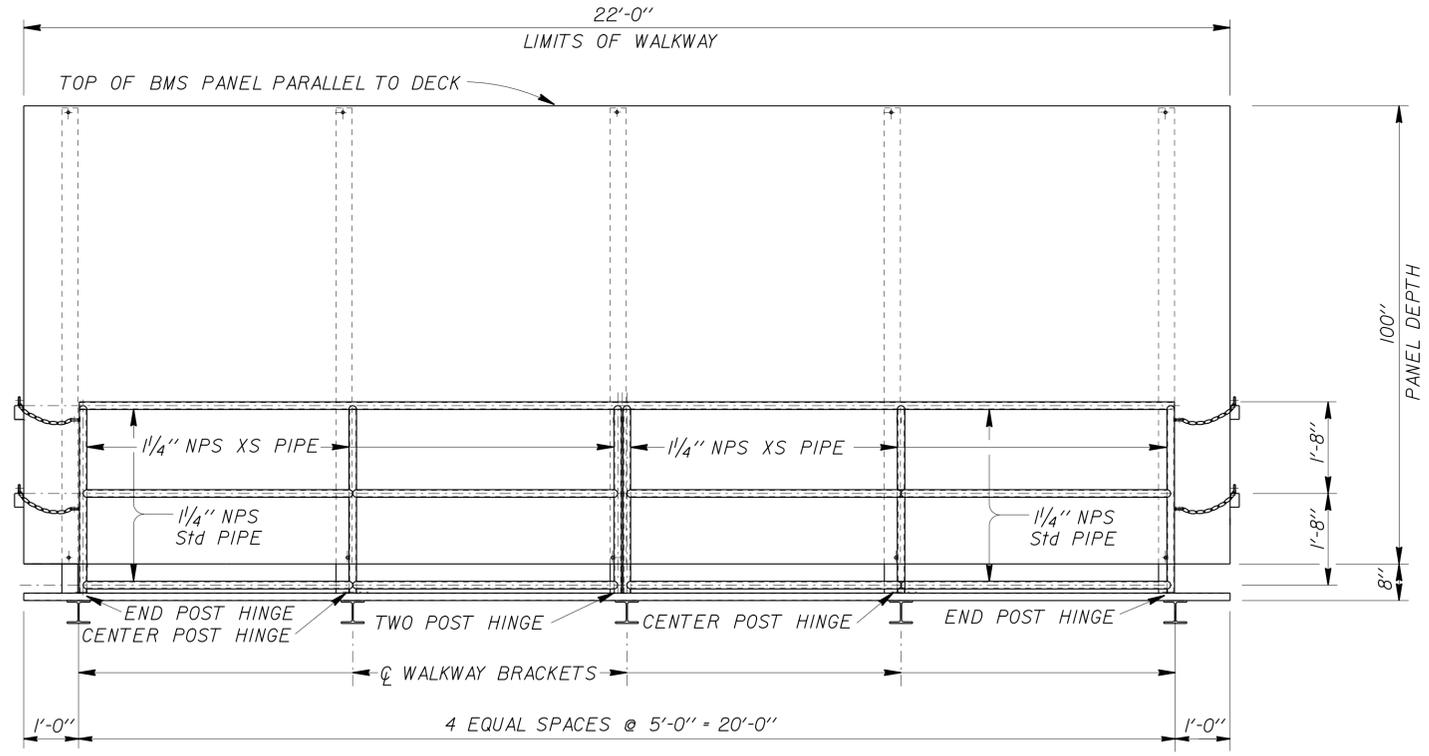

**ELEVATION**  
SIGN No. 40-A ( FEBT ) AND SIGN No. 40-B ( FWBT )

6 ADDED PER ADDENDUM No. 6 DATED NOVEMBER 5, 2014

 NOTE:  
THE CONTRACTOR SHALL VERIFY ALL CONTROLLING FIELD DIMENSIONS BEFORE ORDERING OR FABRICATING ANY MATERIAL.




BRANCH CHIEF <b>JEFF WOODY</b>	DESIGN	BY <b>JUAN JAUREGUI</b>	CHECKED <b>ARLENA GUTIERREZ</b>	STATE OF CALIFORNIA DEPARTMENT OF TRANSPORTATION	DIVISION OF ENGINEERING SERVICES DESIGN AND TECHNICAL SERVICES SPECIAL DESIGNS BRANCH <b>A</b>	BRIDGE NO.	<b>54-1296</b>	<b>LENWOOD ROAD OVERCROSSING</b> <b>BRIDGE MOUNTED SIGN - PLAN AND ELEVATION</b>	<b>SDS-2</b>
	DETAILS	BY <b>R. YEE</b>	CHECKED <b>JUAN JAUREGUI</b>			POST MILE	<b>R30.4</b>		
(ENGLISH) SPECIAL DESIGNS BRANCH BORDER SHEET (REV. 7-1-09)				ORIGINAL SCALE IN INCHES FOR REDUCED PLANS 0 1 2 3	UNIT: 3619 PROJECT NUMBER & PHASE: 0800000010-1	CONTRACT NO.: 08-043511	DISREGARD PRINTS BEARING EARLIER REVISION DATES	REVISION DATES 7/27/13 11/6/13 8/12/13 9/11/13	SHEET OF

USERNAME => s128843 DATE PLOTTED => 05-NOV-2014 TIME PLOTTED => 11:31

DIST	COUNTY	ROUTE	POST MILES TOTAL PROJECT	SHEET No	TOTAL SHEETS
08	SBd	58	R22.2/R31.1	717C	900
 REGISTERED CIVIL ENGINEER			DATE	11/6/13	
PLANS APPROVAL DATE 5-5-14					
<small>The State of California or its officers or agents shall not be responsible for the accuracy or completeness of electronic copies of this plan sheet.</small>					

**6**

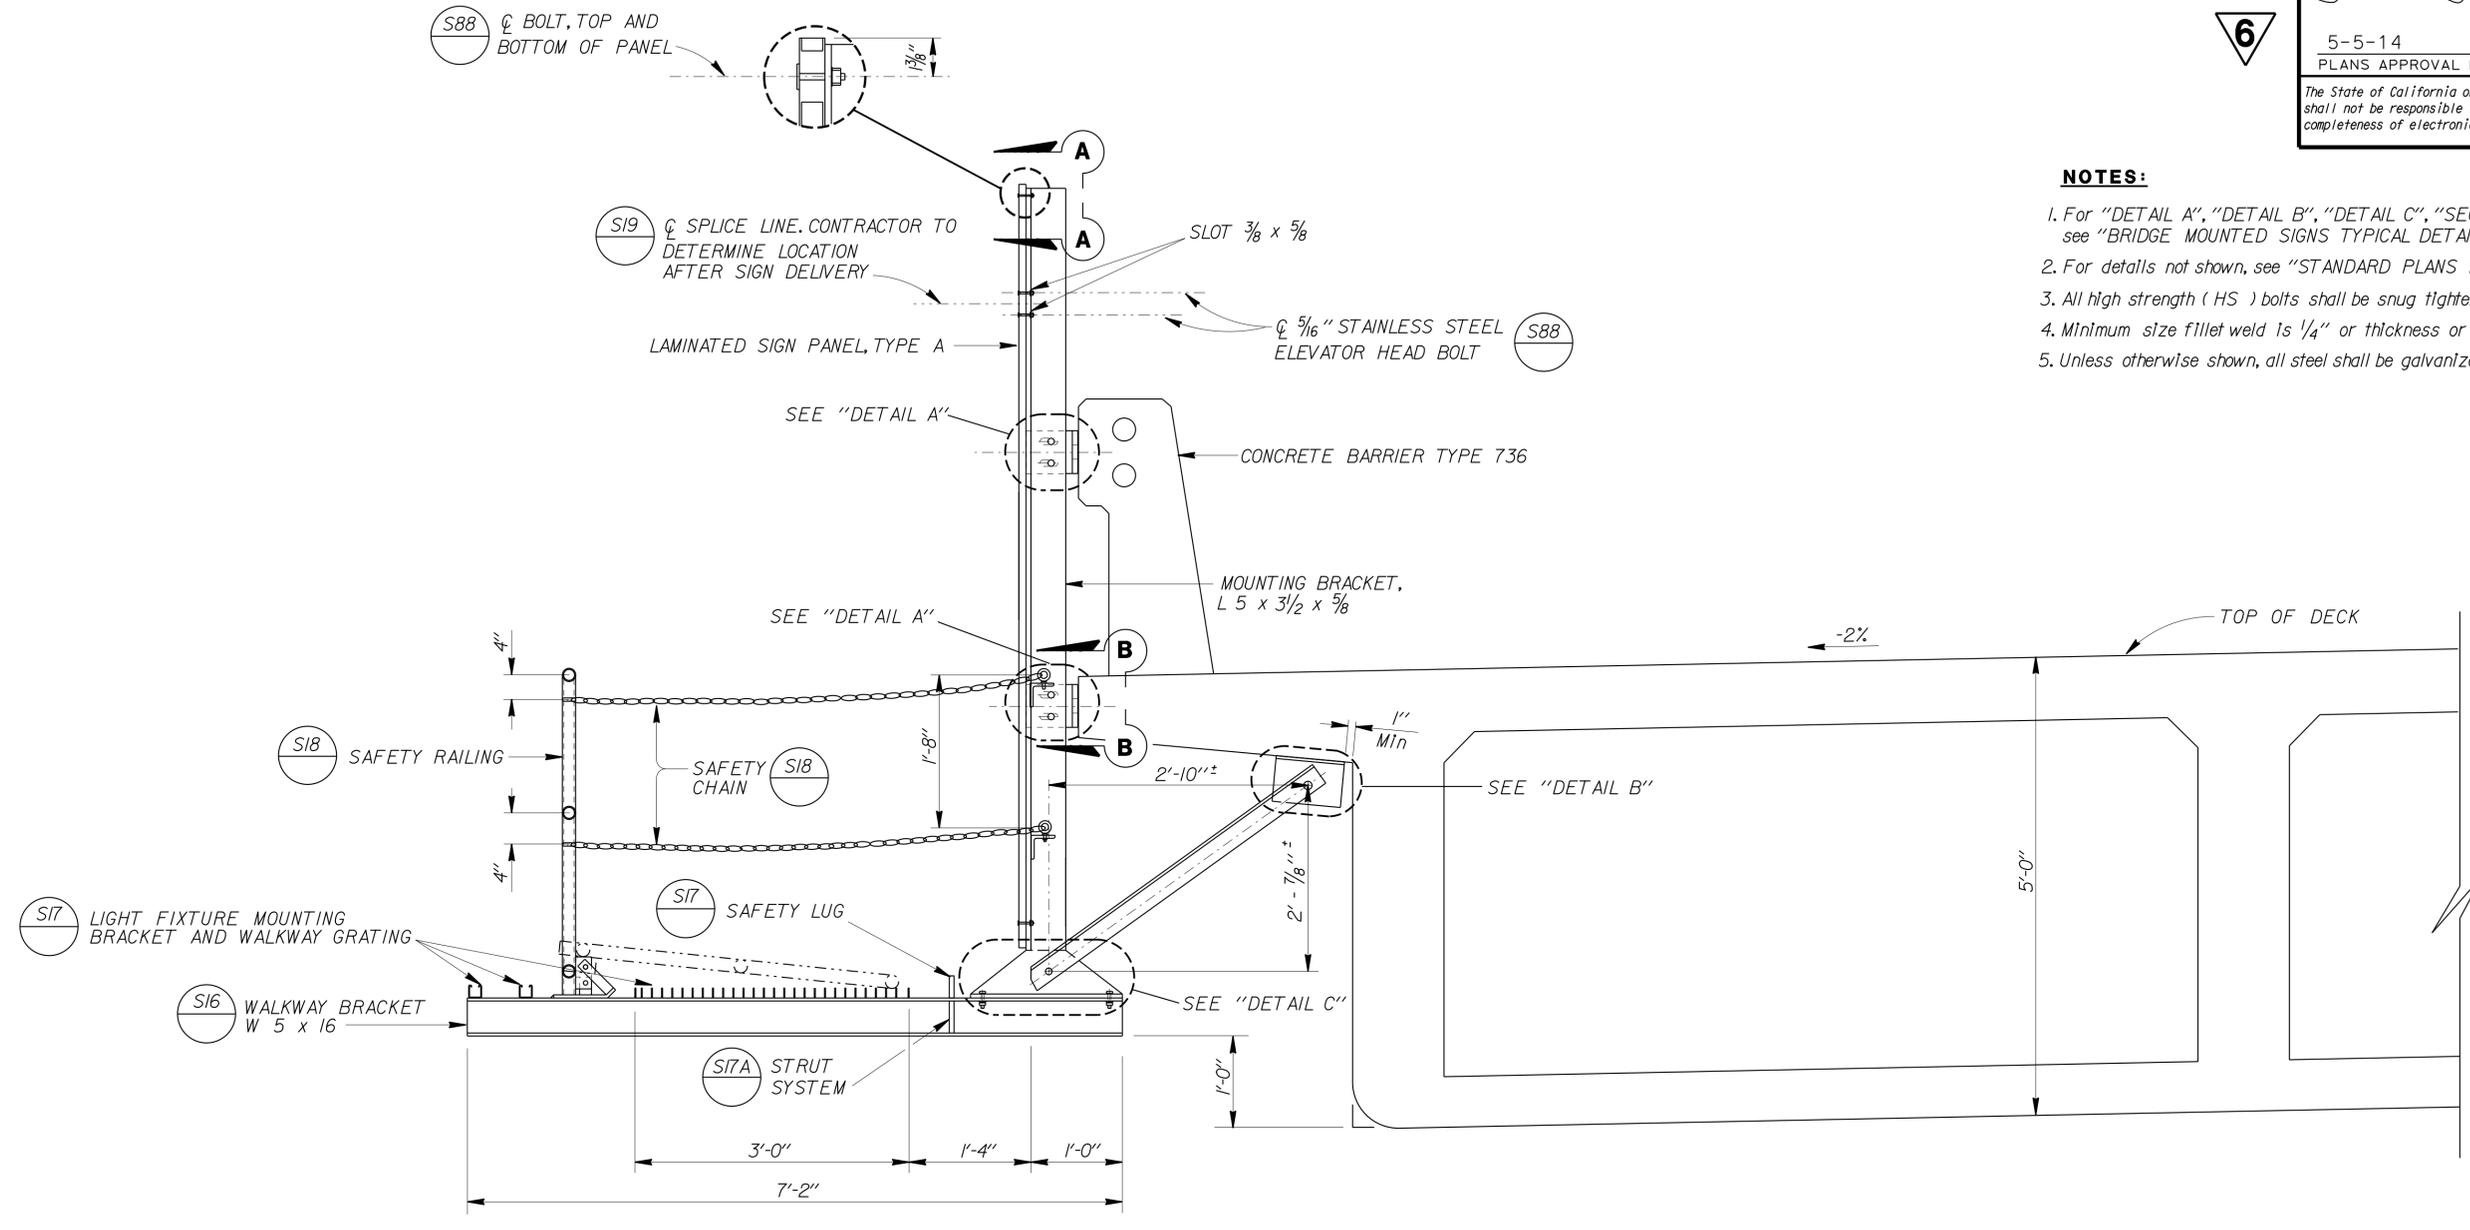


- NOTES:**
1. For "DETAIL A", "DETAIL B", "DETAIL C", "SECTION A-A", and "SECTION B-B", see "BRIDGE MOUNTED SIGNS TYPICAL DETAILS" sheet.
  2. For details not shown, see "STANDARD PLANS 2010".
  3. All high strength (HS) bolts shall be snug tightened.
  4. Minimum size fillet weld is 1/4" or thickness or thinner part unless noted otherwise.
  5. Unless otherwise shown, all steel shall be galvanized after fabrication.

**TYPICAL SECTION**  
BRIDGE MOUNTED SIGN ( FBT )


**6** ADDED PER ADDENDUM No. 6 DATED NOVEMBER 5, 2014

 NOTE:  
THE CONTRACTOR SHALL VERIFY ALL CONTROLLING FIELD DIMENSIONS BEFORE ORDERING OR FABRICATING ANY MATERIAL.




BRANCH CHIEF <b>JEFF WOODY</b>	DESIGN	BY <b>JUAN JAUREGUI</b>	CHECKED <b>ARLENA GUTIERREZ</b>	<b>STATE OF CALIFORNIA</b> DEPARTMENT OF TRANSPORTATION	DIVISION OF ENGINEERING SERVICES DESIGN AND TECHNICAL SERVICES <b>SPECIAL DESIGNS BRANCH</b>	BRIDGE NO.	<b>54-1296</b>	<b>LENWOOD ROAD OVERCROSSING</b> <b>BRIDGE MOUNTED SIGN - TYPICAL SECTION No. 1</b>	<b>SDS-3</b>
	DETAILS	BY <b>R. YEE</b>	CHECKED <b>JUAN JAUREGUI</b>			POST MILE	<b>R30.4</b>		
	QUANTITIES	BY <b>JUAN JAUREGUI</b>	CHECKED <b>ARLENA GUTIERREZ</b>			NO SCALE			
(ENGLISH) SPECIAL DESIGNS BRANCH BORDER SHEET (REV. 7-1-09)									
ORIGINAL SCALE IN INCHES FOR REDUCED PLANS					UNIT: 3619		PROJECT NUMBER & PHASE: 0800000010-1		CONTRACT NO.: 08-043511
DISREGARD PRINTS BEARING EARLIER REVISION DATES									
REVISION DATES: 11/6/13, 11/6/13, 5/14/13, 9/11/13									

 USERNAME => s128843 DATE PLOTTED => 05-NOV-2014 TIME PLOTTED => 11:31

DIST	COUNTY	ROUTE	POST MILES TOTAL PROJECT	SHEET No	TOTAL SHEETS
08	SBd	58	R22.2/R31.1	717D	900
 REGISTERED CIVIL ENGINEER DATE 11/6/13					
5-5-14 PLANS APPROVAL DATE					
<small>The State of California or its officers or agents shall not be responsible for the accuracy or completeness of electronic copies of this plan sheet.</small>					

**6**

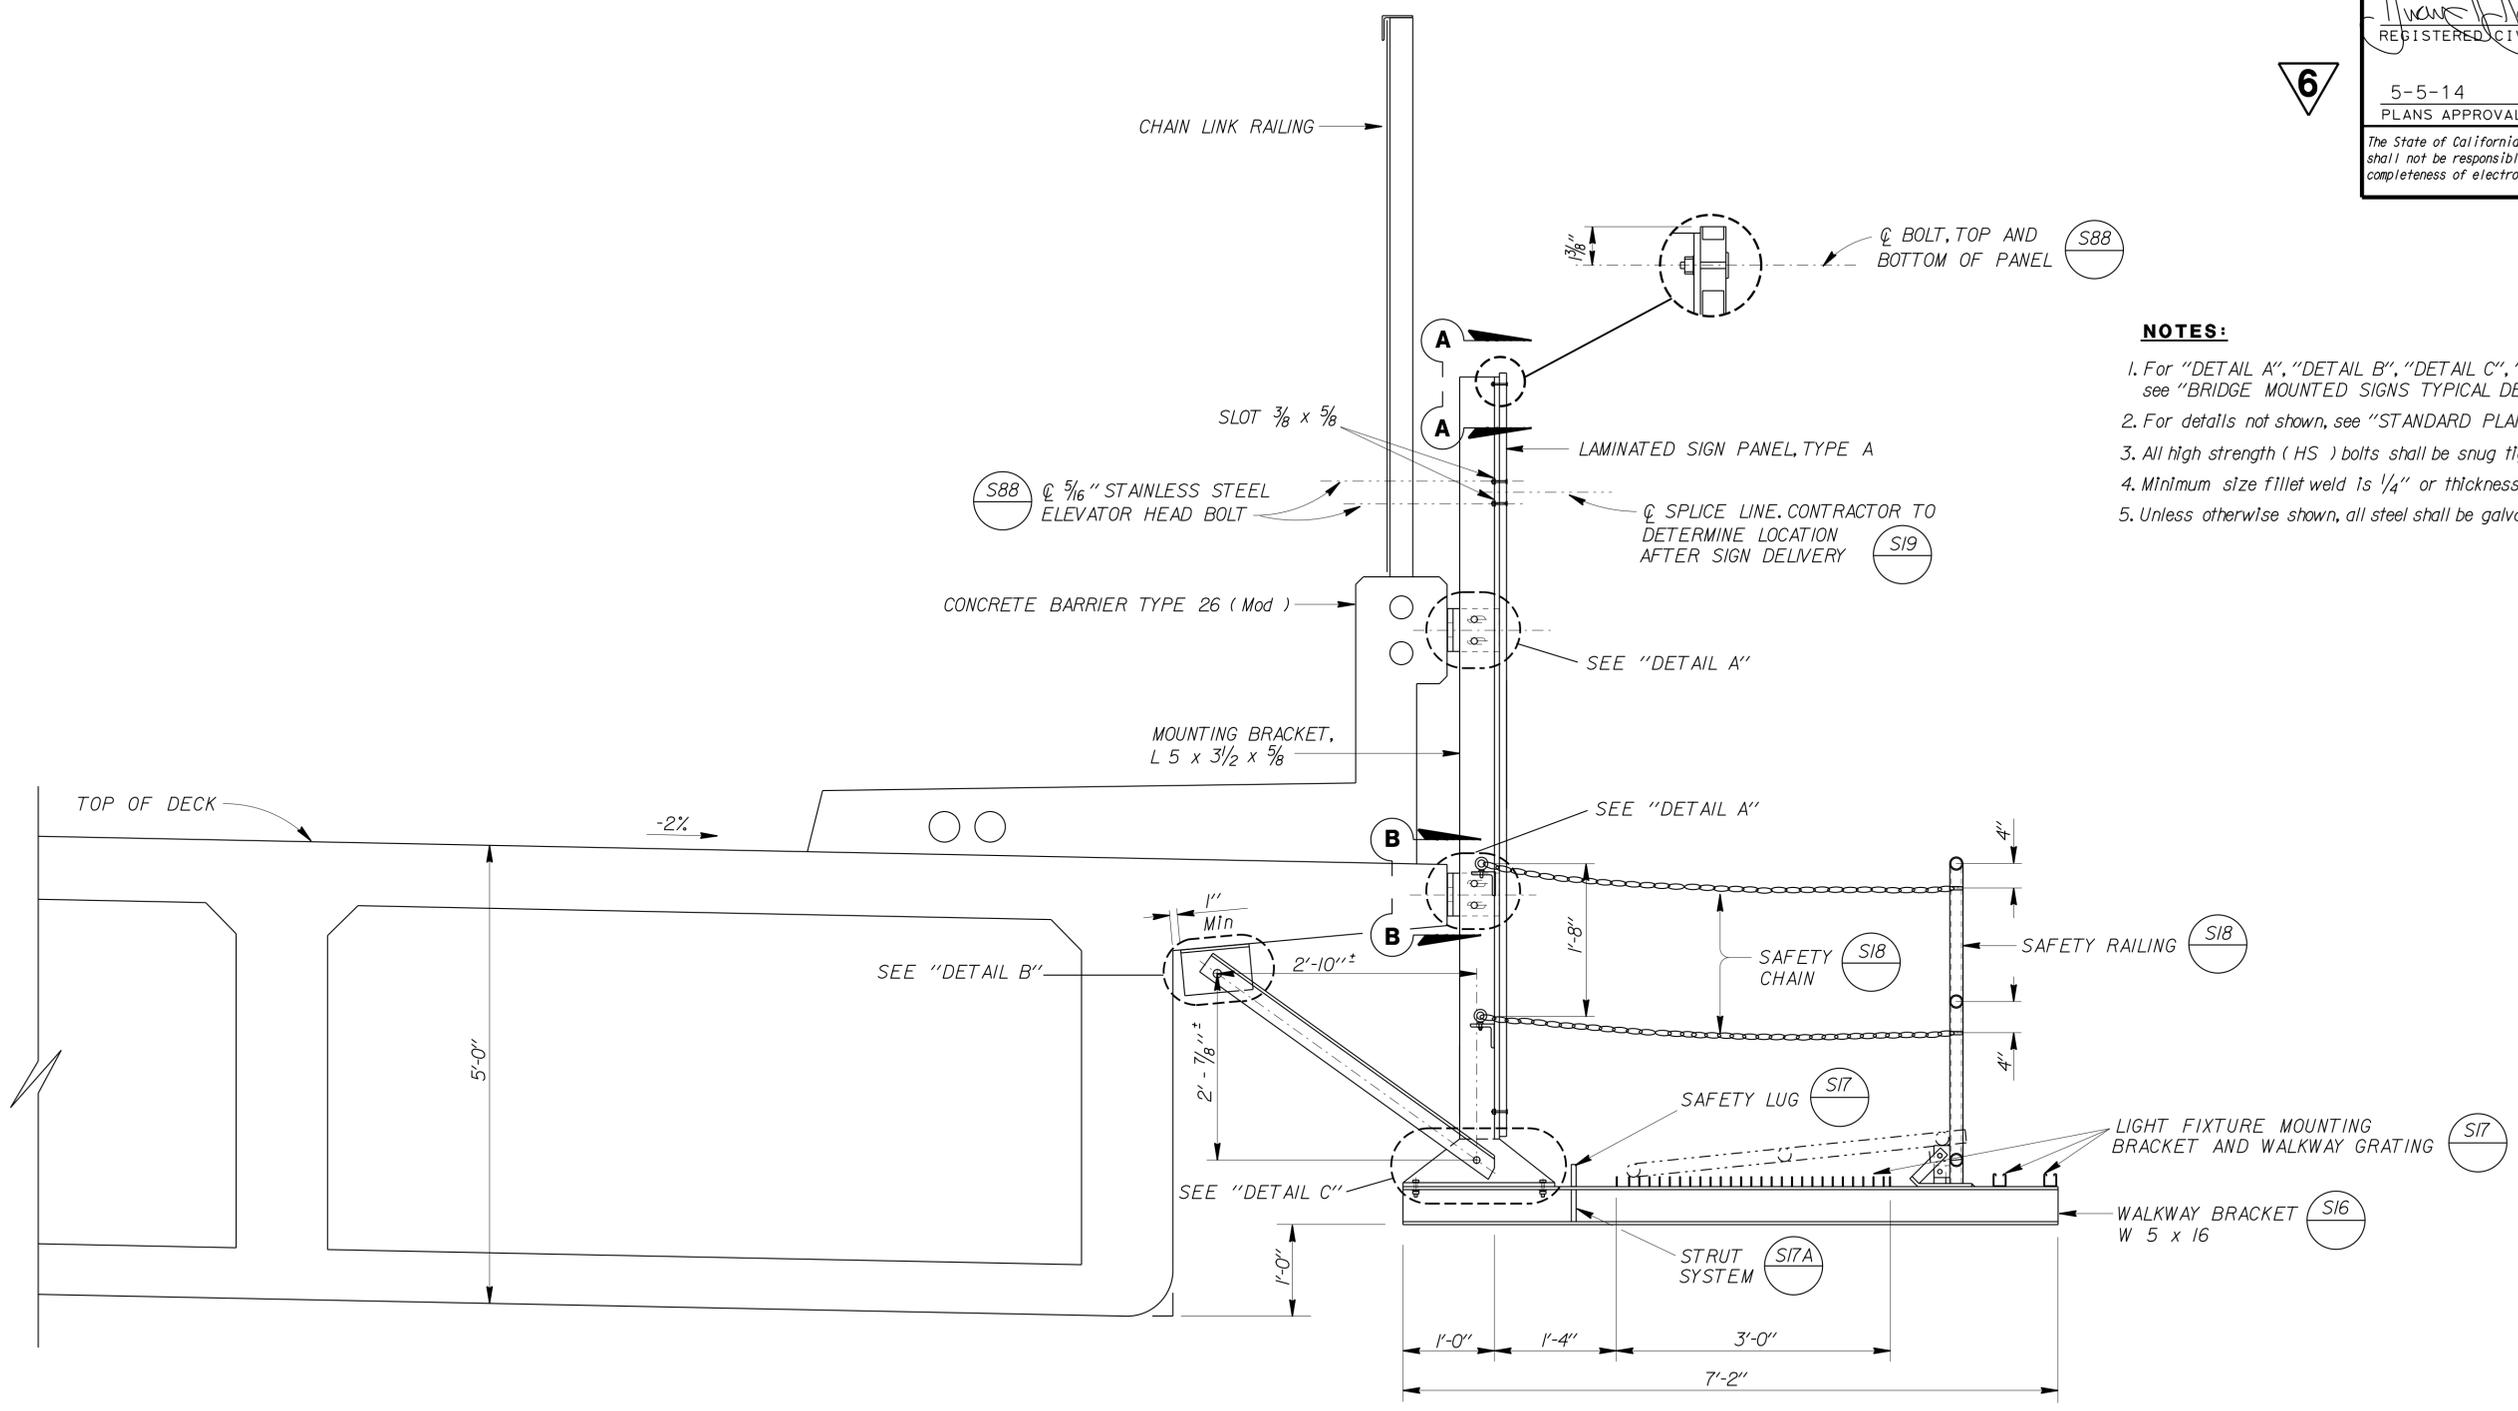


- NOTES:**
1. For "DETAIL A", "DETAIL B", "DETAIL C", "SECTION A-A", and "SECTION B-B", see "BRIDGE MOUNTED SIGNS TYPICAL DETAILS" sheet.
  2. For details not shown, see "STANDARD PLANS 2010".
  3. All high strength (HS) bolts shall be snug tightened.
  4. Minimum size fillet weld is 1/4" or thickness or thinner part unless noted otherwise.
  5. Unless otherwise shown, all steel shall be galvanized after fabrication.

**TYPICAL SECTION**  
**BRIDGE MOUNTED SIGN (FWBT)**

**6** ADDED PER ADDENDUM No. 6 DATED NOVEMBER 5, 2014

 NOTE:  
 THE CONTRACTOR SHALL VERIFY ALL CONTROLLING FIELD DIMENSIONS BEFORE ORDERING OR FABRICATING ANY MATERIAL.




BRANCH CHIEF <b>JEFF WOODY</b>	DESIGN	BY <b>JUAN JAUREGUI</b>	CHECKED <b>ARLENA GUTIERREZ</b>	<b>STATE OF CALIFORNIA</b> DEPARTMENT OF TRANSPORTATION	DIVISION OF ENGINEERING SERVICES DESIGN AND TECHNICAL SERVICES <b>SPECIAL DESIGNS BRANCH A</b>	BRIDGE NO.	<b>54-1296</b>	<b>LENWOOD ROAD OVERCROSSING</b> <b>BRIDGE MOUNTED SIGN - TYPICAL SECTION No. 2</b>	<b>SDS-4</b>
	DETAILS	BY <b>R. YEE</b>	CHECKED <b>JUAN JAUREGUI</b>			POST MILE	<b>R30.4</b>		
	QUANTITIES	BY <b>JUAN JAUREGUI</b>	CHECKED <b>ARLENA GUTIERREZ</b>						

(ENGLISH) SPECIAL DESIGNS BRANCH BORDER SHEET (REV. 7-1-09)	ORIGINAL SCALE IN INCHES FOR REDUCED PLANS	0	1	2	3	UNIT: 3619	PROJECT NUMBER & PHASE: 080000010-1	CONTRACT NO.: 08-043511	DISREGARD PRINTS BEARING EARLIER REVISION DATES	REVISION DATES	SHEET	OF	
										7/22/13	11/6/13	8/12/13	9/11/13


USERNAME => s128843 DATE PLOTTED => 05-NOV-2014 TIME PLOTTED => 11:31

DIST	COUNTY	ROUTE	POST MILES TOTAL PROJECT	SHEET No	TOTAL SHEETS
08	SBd	58	R22.2/R31.1	717E	900
			11/6/13		
REGISTERED CIVIL ENGINEER DATE					
5-5-14			PLANS APPROVAL DATE		
The State of California or its officers or agents shall not be responsible for the accuracy or completeness of electronic copies of this plan sheet.					


**6**

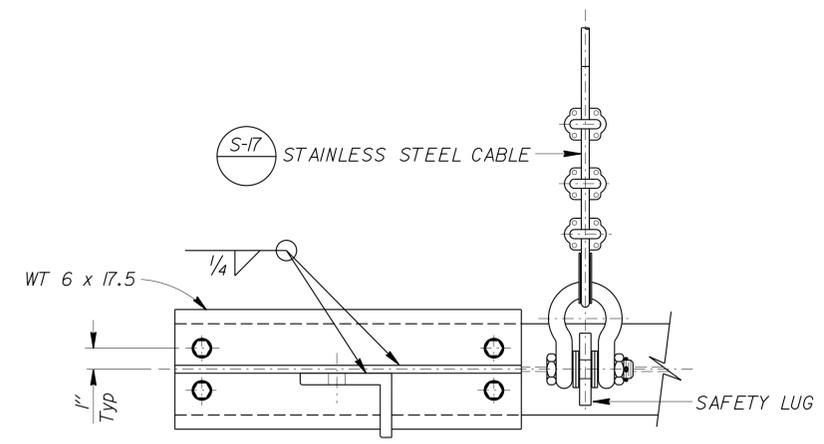


**SECTION C-C**

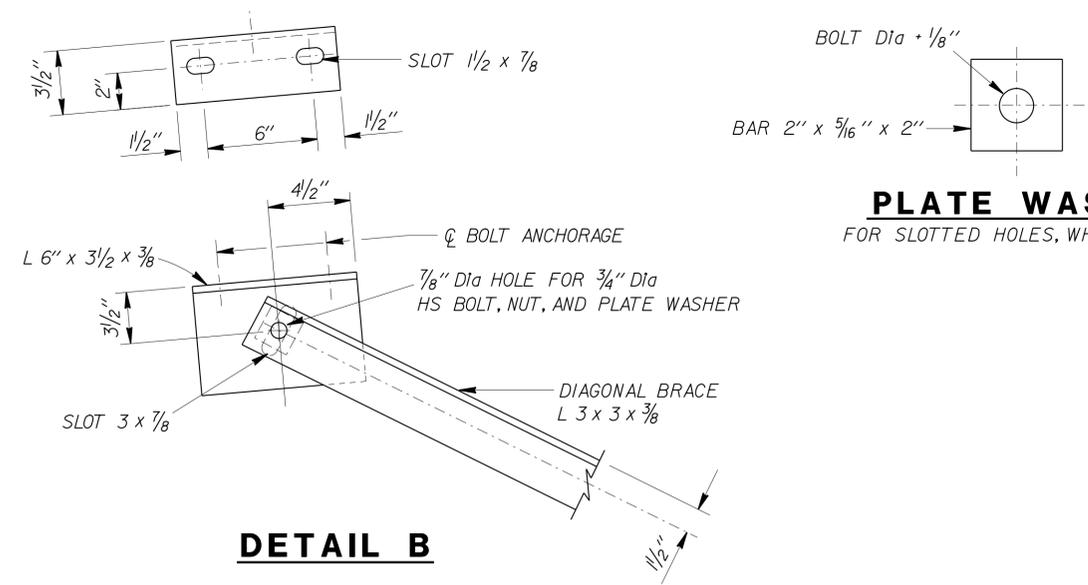


**PLATE WASHER**  
FOR SLOTTED HOLES, WHERE NOTED

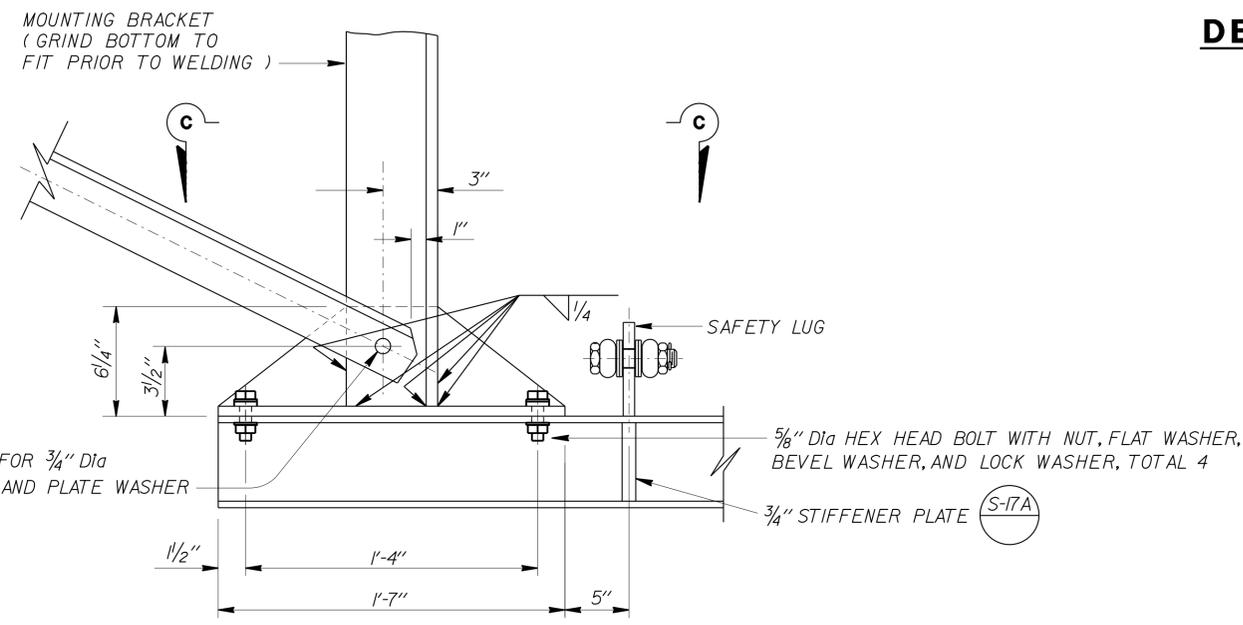


**DETAIL C**

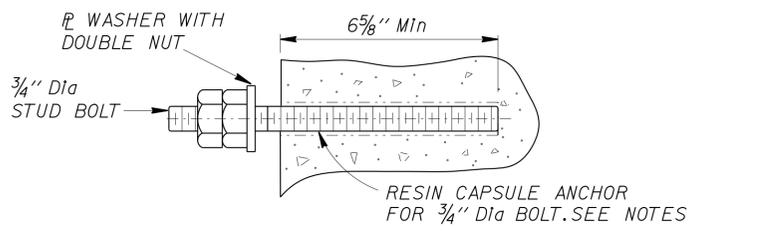


**RESIN CAPSULE BOLT ANCHORAGE**

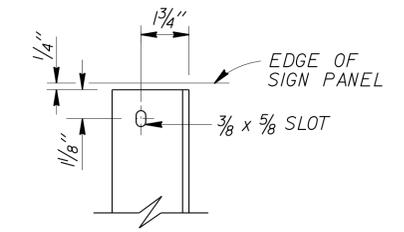


**SECTION A-A**

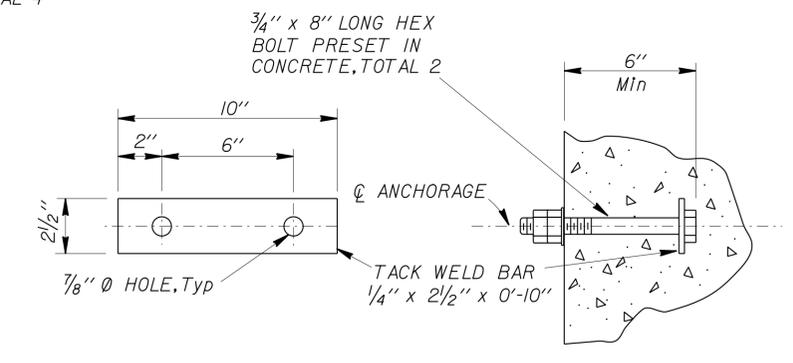

**ALTERNATIVE CIP BOLT ANCHORAGE**

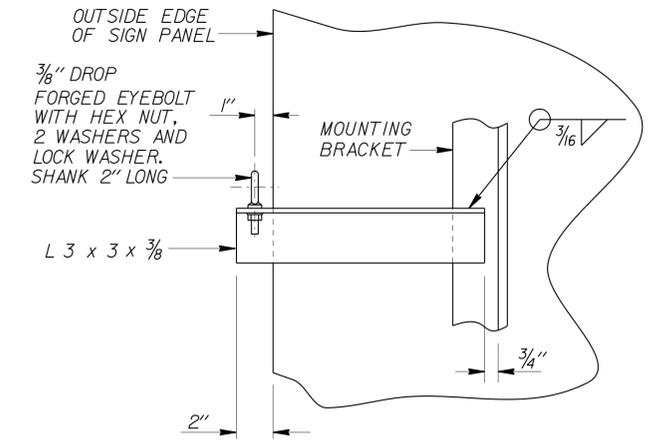

**SECTION B-B**

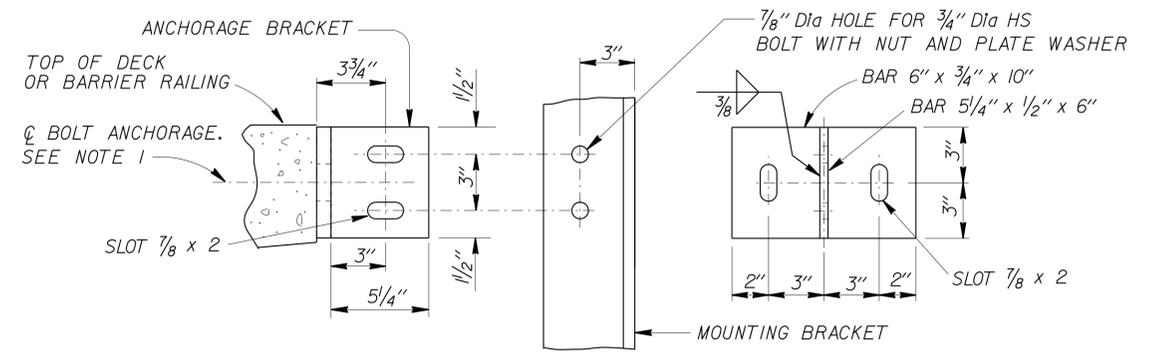


**DETAIL A**

NOTE:  
THE CONTRACTOR SHALL VERIFY ALL CONTROLLING FIELD DIMENSIONS BEFORE ORDERING OR FABRICATING ANY MATERIAL.

**6**

 **ADDED PER ADDENDUM No. 6 DATED NOVEMBER 5, 2014**



BRANCH CHIEF <b>JEFF WOODY</b>	DESIGN BY <b>JUAN JAUREGUI</b>	CHECKED <b>ARLENA GUTIERREZ</b>	STATE OF CALIFORNIA DEPARTMENT OF TRANSPORTATION	DIVISION OF ENGINEERING SERVICES DESIGN AND TECHNICAL SERVICES SPECIAL DESIGNS BRANCH <b>A</b>	BRIDGE NO. 54-1296	<b>LENWOOD ROAD OVERCROSSING</b> <b>BRIDGE MOUNTED SIGN - TYPICAL DETAILS</b>	<b>SDS-5</b>
	DETAILS BY <b>R. YEE</b>	CHECKED <b>JUAN JAUREGUI</b>			POST MILE R30.4		
QUANTITIES BY <b>JUAN JAUREGUI</b>	CHECKED <b>ARLENA GUTIERREZ</b>		UNIT: 3619 PROJECT NUMBER & PHASE: 080000010-1	CONTRACT NO.: 08-043511	DISREGARD PRINTS BEARING EARLIER REVISION DATES	REVISION DATES: 9/23/13, 11/6/13, 8/14/13, 9/18/13	SHEET OF

(ENGLISH) SPECIAL DESIGNS BRANCH BORDER SHEET (REV. 7-1-09)


ORIGINAL SCALE IN INCHES FOR REDUCED PLANS: 0 1 2 3

FILE => /2013sd/08-043511/sds-5

USERNAME => s128843 DATE PLOTTED => 05-NOV-2014 TIME PLOTTED => 11:31

DIST	COUNTY	ROUTE	POST MILES TOTAL PROJECT	SHEET No	TOTAL SHEETS
08	SBd	58	R22.2/R31.1	717F	900
			11/6/13		
			REGISTERED CIVIL ENGINEER		
			DATE		
			5-5-14		
			PLANS APPROVAL DATE		
<small>The State of California or its officers or agents shall not be responsible for the accuracy or completeness of electronic copies of this plan sheet.</small>					

6

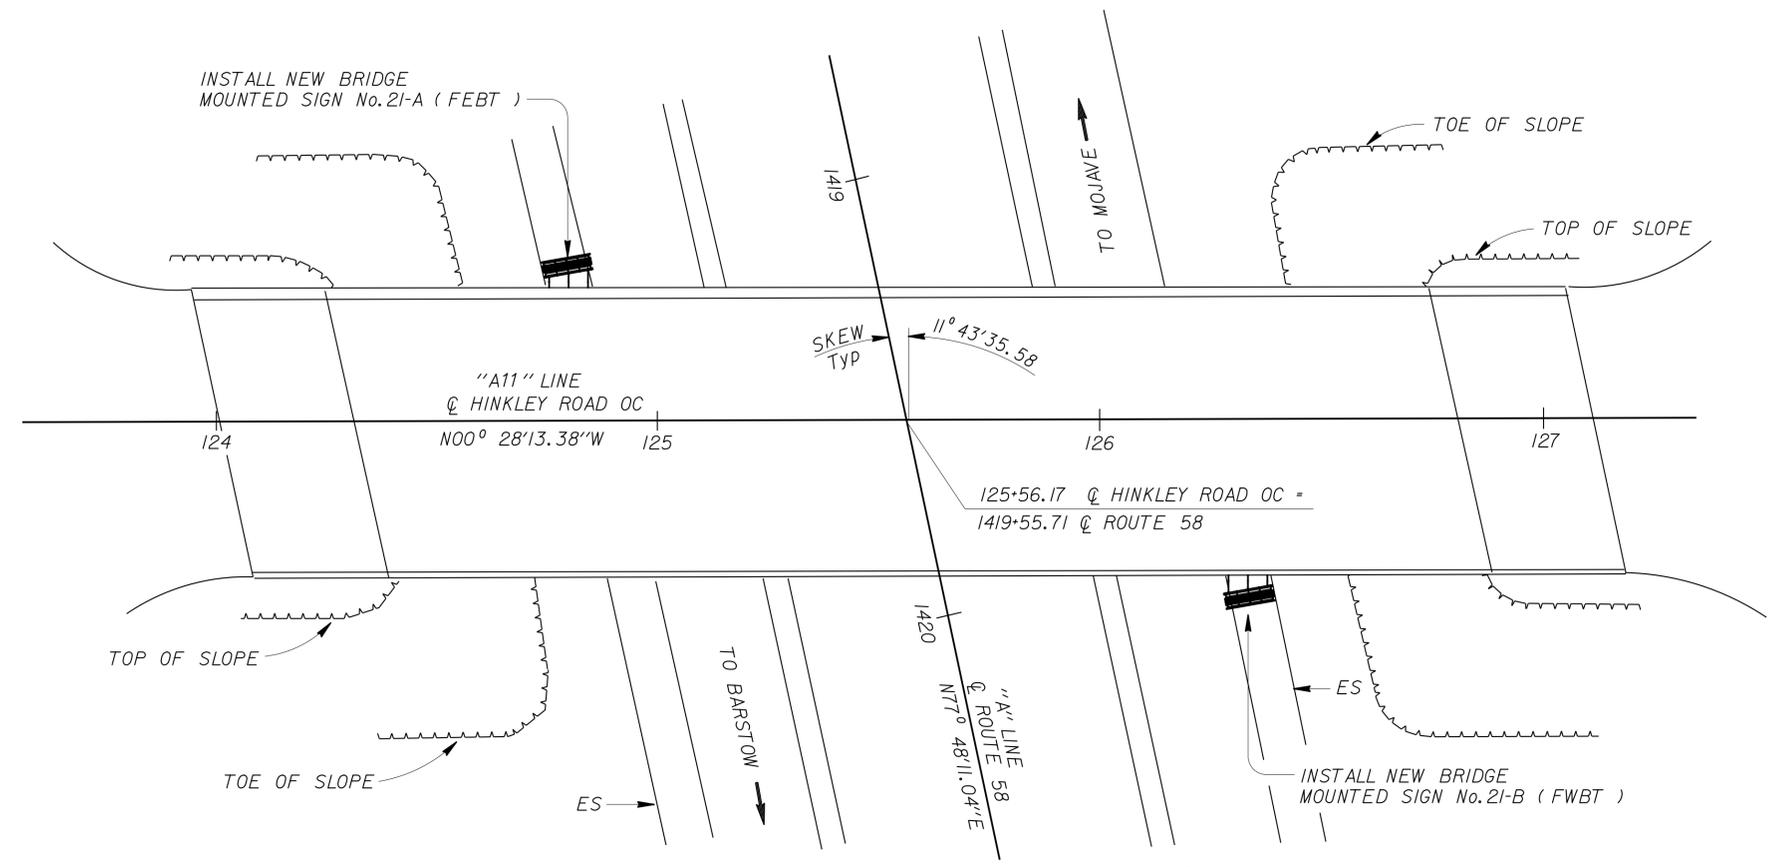


**LOCATION PLAN**


- NOTES:**
1. This plan accurate only for the orientation of the bridge mounted signs relative to the bridges.
  2. For sign locations, see "SIGN PLANS".
  3. For sign illumination equipment, see "ELECTRICAL PLANS".

**STANDARD PLANS 2010**

- A/OA ACRONYMS AND ABBREVIATIONS ( SHEET 1 OF 2 )
- A/OB ACRONYMS AND ABBREVIATIONS ( SHEET 2 OF 2 )

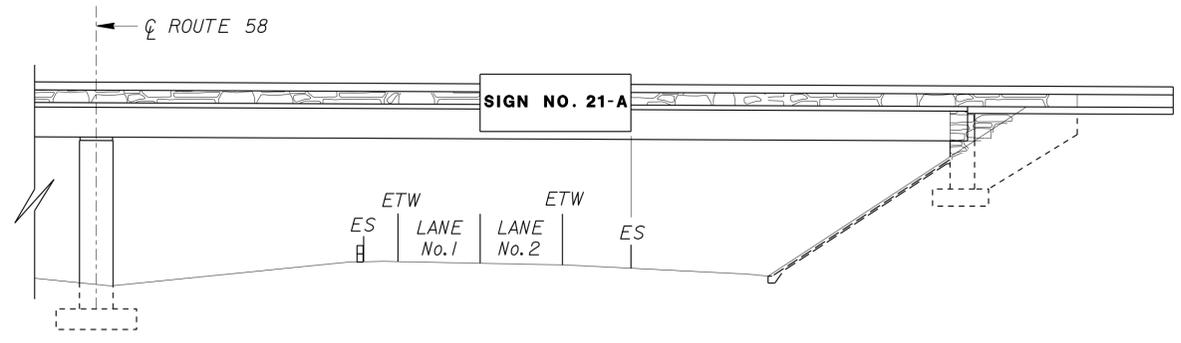


**EASTBOUND ELEVATION**

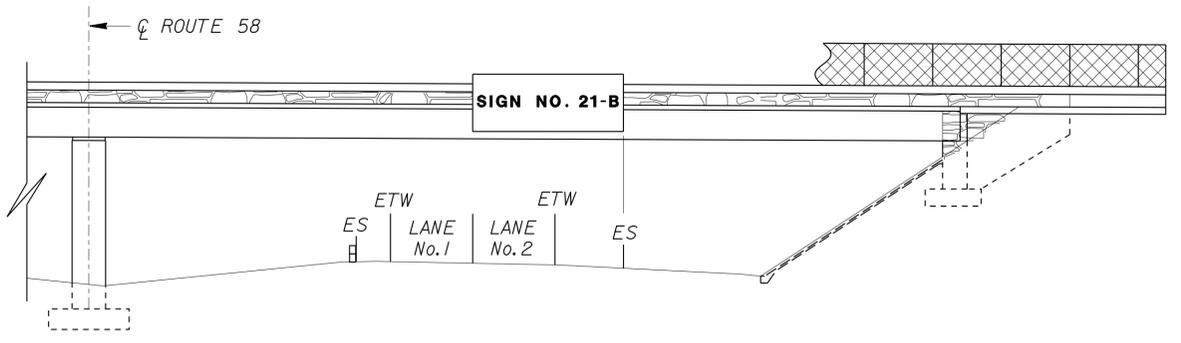

**WESTBOUND ELEVATION**

 
**6** ADDED PER ADDENDUM No. 6 DATED NOVEMBER 5, 2014




NOTE:  
THE CONTRACTOR SHALL VERIFY ALL CONTROLLING FIELD DIMENSIONS BEFORE ORDERING OR FABRICATING ANY MATERIAL.

BRANCH CHIEF <b>JEFF WOODY</b>	DESIGN BY <b>JUAN JAUREGUI</b>	CHECKED <b>ARLENA GUTIERREZ</b>	STATE OF CALIFORNIA DEPARTMENT OF TRANSPORTATION	DIVISION OF ENGINEERING SERVICES DESIGN AND TECHNICAL SERVICES SPECIAL DESIGNS BRANCH <b>A</b>	BRIDGE NO. 54-1295	<b>HINKLEY ROAD OVERCROSSING</b>	<b>SDS-6</b>
	DETAILS BY <b>R. YEE</b>	CHECKED <b>JUAN JAUREGUI</b>			POST MILE R26.4		
QUANTITIES BY <b>JUAN JAUREGUI</b>			CHECKED <b>ARLENA GUTIERREZ</b>		UNIT: 3619 PROJECT NUMBER & PHASE: 080000010-1		CONTRACT NO.: 08-043511
<small>(ENGLISH) SPECIAL DESIGNS BRANCH BORDER SHEET (REV. 7-1-09)</small>				<small>ORIGINAL SCALE IN INCHES FOR REDUCED PLANS</small>		<small>DISREGARD PRINTS BEARING EARLIER REVISION DATES</small>	
				0 1 2 3		REVISION DATES 9/27/13 9/27/13 11/6/13	

 
USERNAME => s128843 DATE PLOTTED => 05-NOV-2014 TIME PLOTTED => 11:31

DIST	COUNTY	ROUTE	POST MILES TOTAL PROJECT	SHEET No	TOTAL SHEETS
08	SBd	58	R22.2/R31.1	717G	900
 REGISTERED CIVIL ENGINEER DATE 11/6/13					
5-5-14 PLANS APPROVAL DATE					
<small>The State of California or its officers or agents shall not be responsible for the accuracy or completeness of electronic copies of this plan sheet.</small>					

6

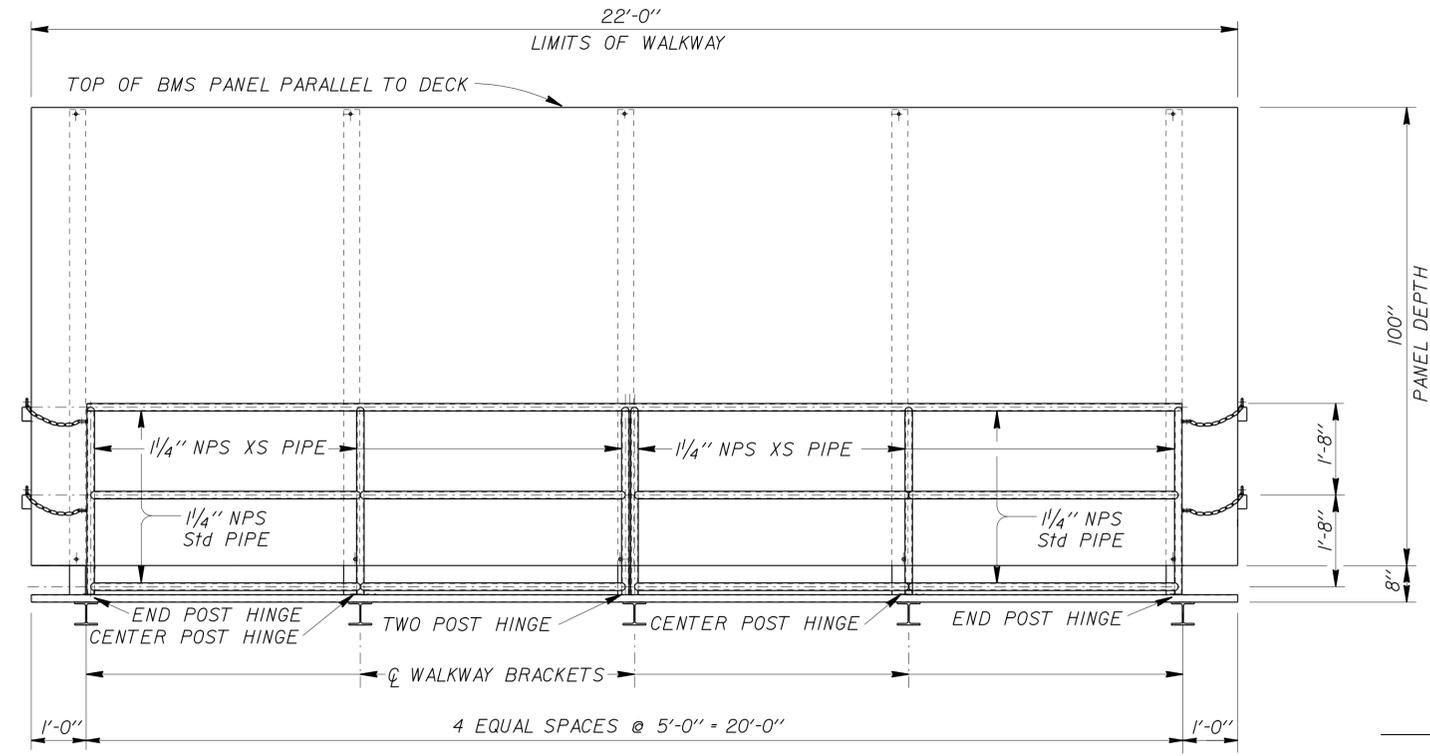

**ELEVATION**  
 SIGN No. 21-A ( FBT ) AND  
 SIGN No. 21-B ( FWBT )

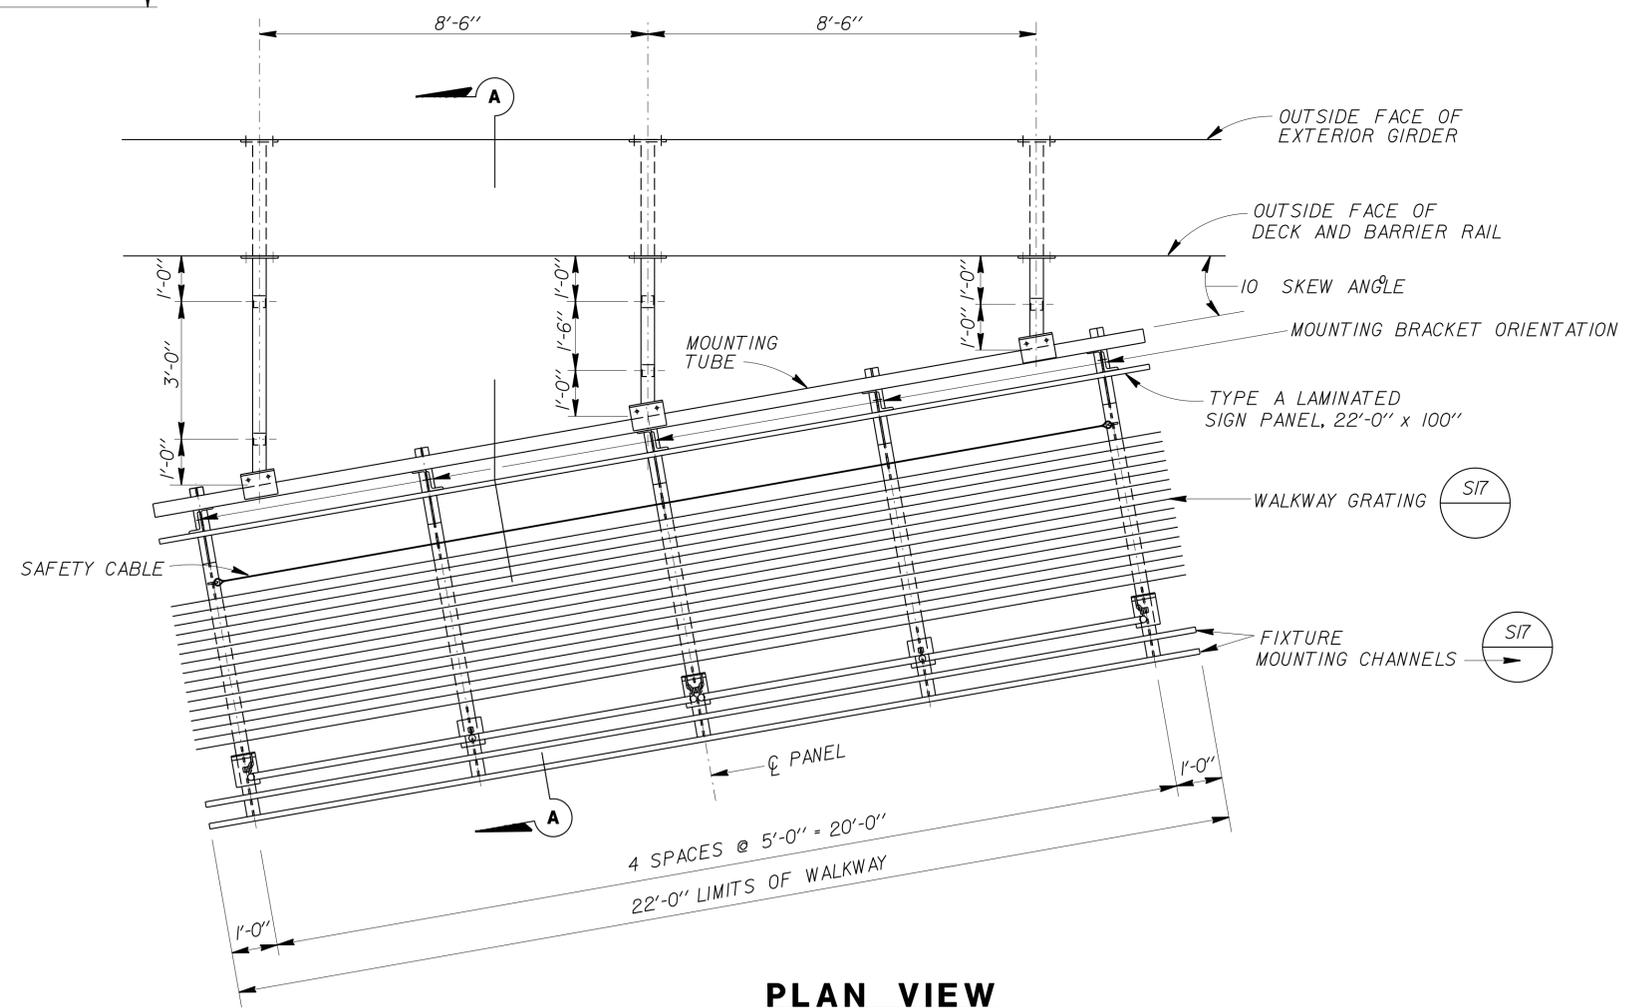

**PLAN VIEW**  
 SIGN No. 21-A ( FBT ) AND  
 SIGN No. 21-B ( FWBT )

NOTE:  
 THE CONTRACTOR SHALL VERIFY ALL  
 CONTROLLING FIELD DIMENSIONS  
 BEFORE ORDERING OR FABRICATING  
 ANY MATERIAL.

6

**ADDED PER ADDENDUM No. 6 DATED NOVEMBER 5, 2014**

STANDARD PLAN SHEET No.  
 DETAIL No.

BRANCH CHIEF <b>JEFF WOODY</b>	DESIGN	BY <b>JUAN JAUREGUI</b>	CHECKED <b>ARLENA GUTIERREZ</b>	<b>STATE OF CALIFORNIA</b> DEPARTMENT OF TRANSPORTATION	DIVISION OF ENGINEERING SERVICES DESIGN AND TECHNICAL SERVICES <b>SPECIAL DESIGNS BRANCH</b>	BRIDGE NO.	<b>54-1295</b>	<b>HINKLEY ROAD OVERCROSSING</b> <b>BRIDGE MOUNTED SIGN - SKEWED</b> <b>PLAN AND ELEVATION</b>	<b>SDS-7</b>
	DETAILS	BY <b>R. YEE</b>	CHECKED <b>JUAN JAUREGUI</b>			POST MILE	<b>R26.4</b>		
	QUANTITIES	BY <b>JUAN JAUREGUI</b>	CHECKED <b>ARLENA GUTIERREZ</b>	NO SCALE		UNIT: 3619 PROJECT NUMBER & PHASE: 080000010-1		CONTRACT NO.: 08-043511	

(ENGLISH) SPECIAL DESIGNS BRANCH BORDER SHEET (REV. 7-1-09)

ORIGINAL SCALE IN INCHES FOR REDUCED PLANS

0 1 2 3

DISREGARD PRINTS BEARING EARLIER REVISION DATES

REVISION DATES


SHEET OF

FILE => /2013sd/08-043510/sds-7

USERNAME => s128843 DATE PLOTTED => 05-NOV-2014 TIME PLOTTED => 11:31

DIST	COUNTY	ROUTE	POST MILES TOTAL PROJECT	SHEET No	TOTAL SHEETS
08	SBd	58	R22.2/R31.1	717H	900
 REGISTERED CIVIL ENGINEER DATE 11/6/13					
5-5-14			PLANS APPROVAL DATE		
The State of California or its officers or agents shall not be responsible for the accuracy or completeness of electronic copies of this plan sheet.					

**6**

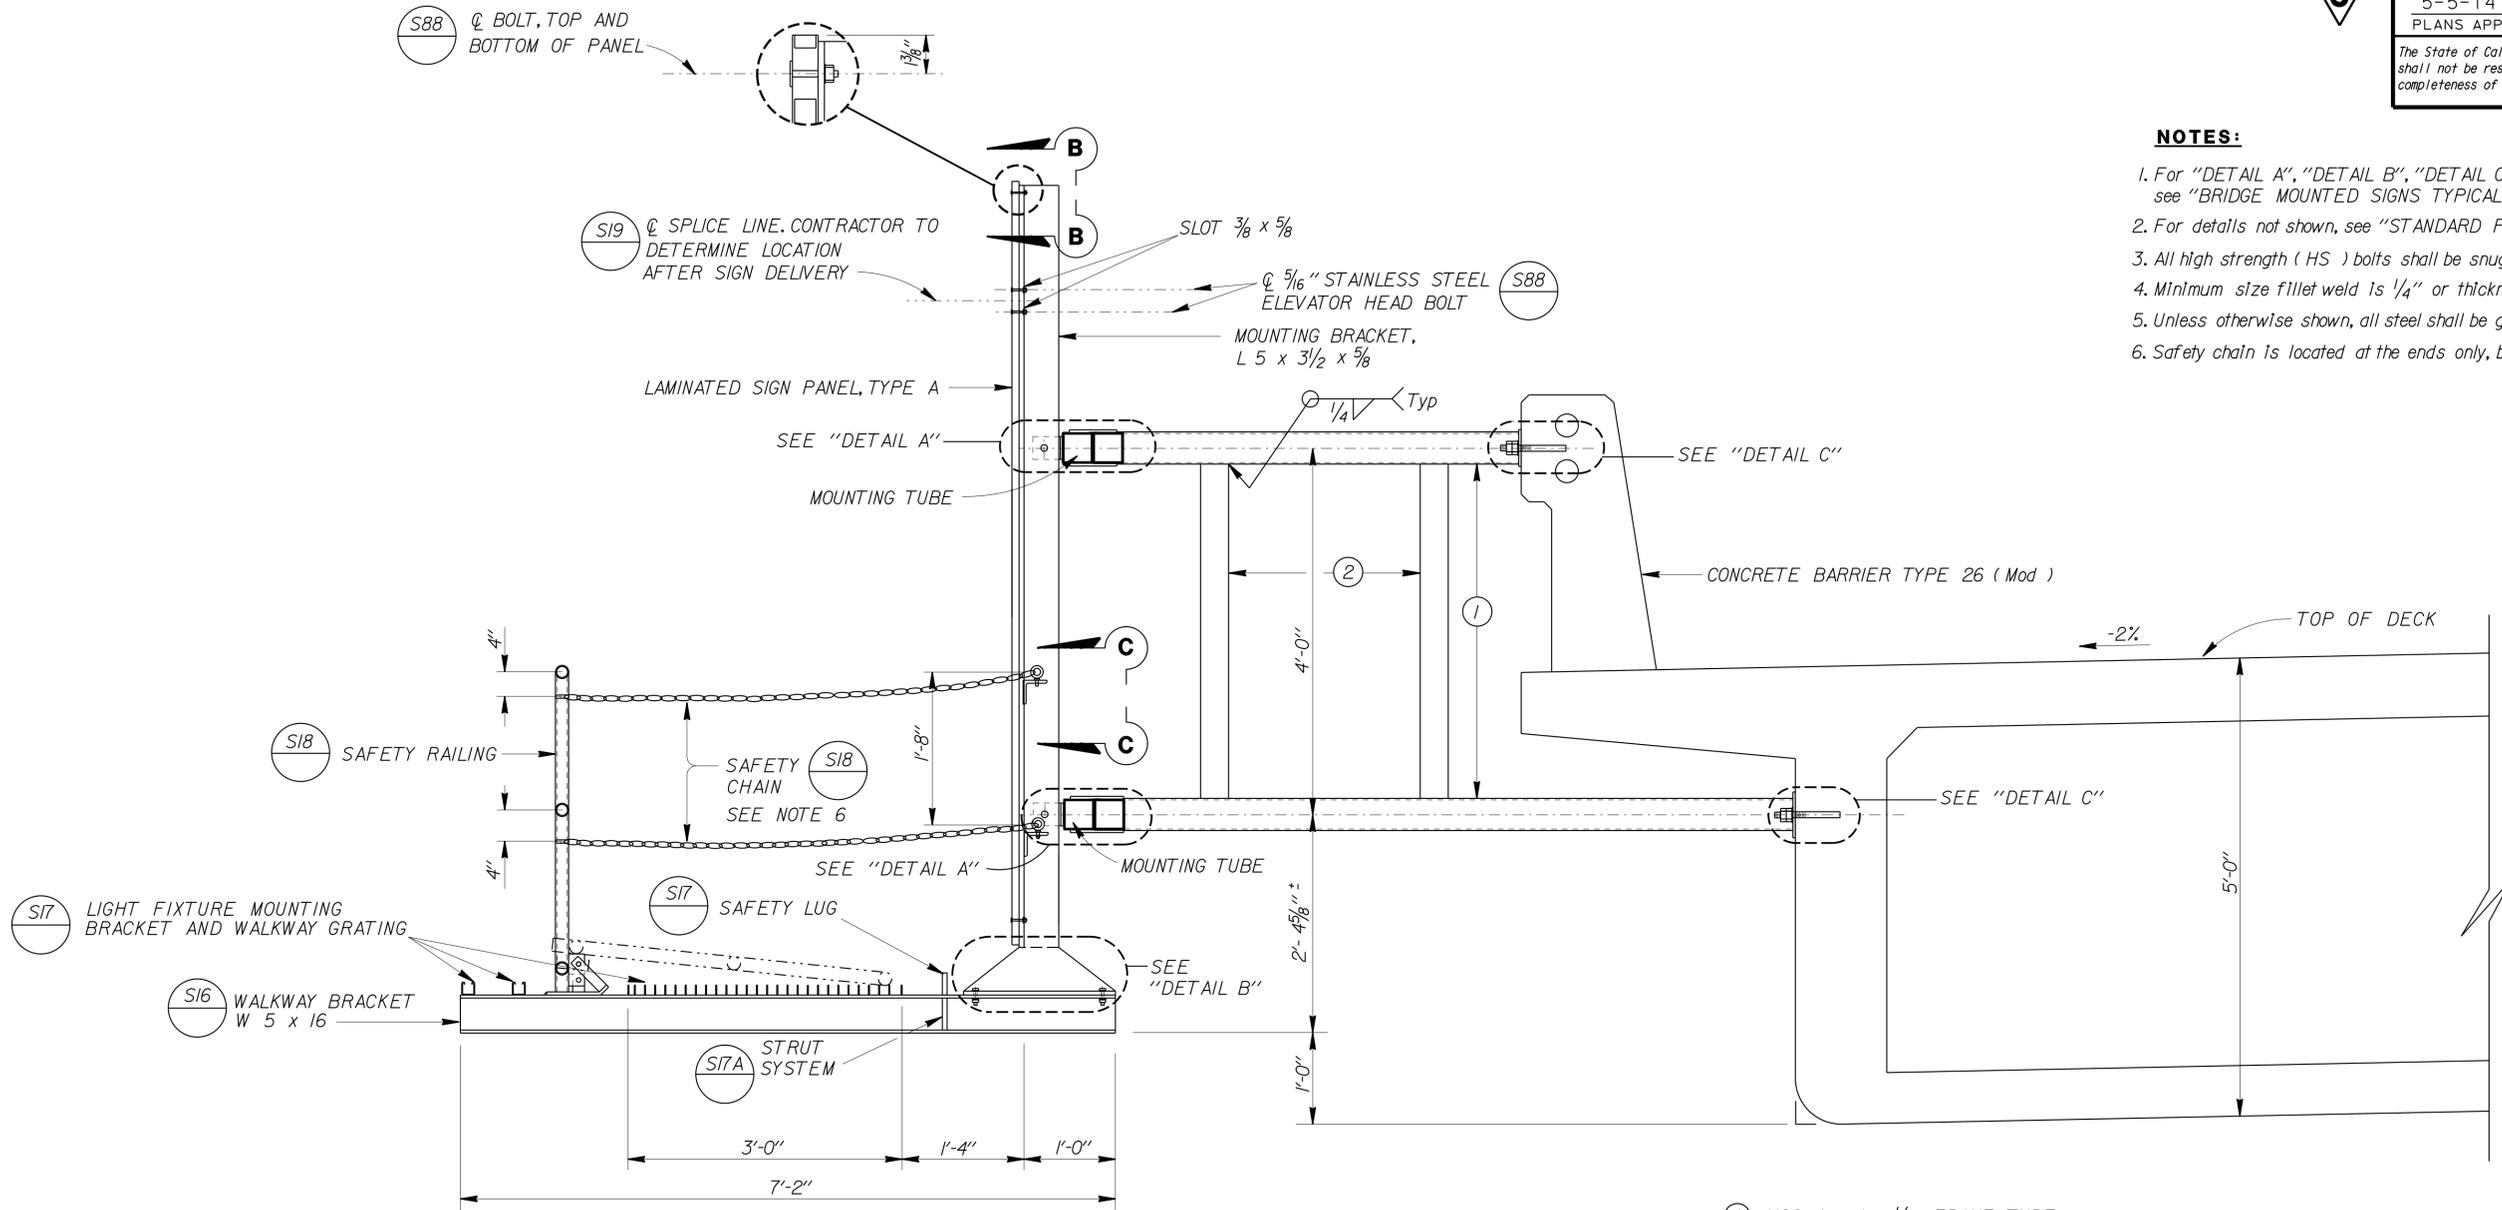


- NOTES:**
1. For "DETAIL A", "DETAIL B", "DETAIL C", "SECTION B-B", and "SECTION C-C", see "BRIDGE MOUNTED SIGNS TYPICAL DETAILS" sheet.
  2. For details not shown, see "STANDARD PLANS 2010".
  3. All high strength (HS) bolts shall be snug tightened.
  4. Minimum size fillet weld is 1/4" or thickness of thinner part unless noted otherwise.
  5. Unless otherwise shown, all steel shall be galvanized after fabrication.
  6. Safety chain is located at the ends only, but is shown here for clarity.

**SECTION A-A**  
BRIDGE MOUNTED SIGN ( FEBT )

- ① HSS 4 x 4 x 1/4 FRAME TUBE
- ② HSS 3 1/2 x 3 1/2 x 1/4 VERTICAL TUBE

**6** ADDED PER ADDENDUM No. 6 DATED NOVEMBER 5, 2014

 NOTE:  
THE CONTRACTOR SHALL VERIFY ALL CONTROLLING FIELD DIMENSIONS BEFORE ORDERING OR FABRICATING ANY MATERIAL.






BRANCH CHIEF <b>JEFF WOODY</b>	DESIGN	BY <b>JUAN JAUREGUI</b>	CHECKED <b>ARLENA GUTIERREZ</b>	STATE OF CALIFORNIA DEPARTMENT OF TRANSPORTATION	DIVISION OF ENGINEERING SERVICES DESIGN AND TECHNICAL SERVICES SPECIAL DESIGNS BRANCH <b>A</b>	BRIDGE NO.	<b>54-1295</b>	<b>HINKLEY ROAD OVERCROSSING</b> <b>BRIDGE MOUNTED SIGN - SKEWED</b> <b>TYPICAL SECTION No. 1</b>	<b>SDS-8</b>
	DETAILS	BY <b>R. YEE</b>	CHECKED <b>JUAN JAUREGUI</b>			POST MILE	<b>R26.4</b>		
	QUANTITIES	BY <b>JUAN JAUREGUI</b>	CHECKED <b>ARLENA GUTIERREZ</b>			NO SCALE			
(ENGLISH) SPECIAL DESIGNS BRANCH BORDER SHEET (REV. 7-1-09)									
ORIGINAL SCALE IN INCHES FOR REDUCED PLANS					UNIT: 3619 PROJECT NUMBER & PHASE: 0800000010-1		CONTRACT NO.: 08-043511		DISREGARD PRINTS BEARING EARLIER REVISION DATES
					0 1 2 3		REVISION DATES 9/18/13 9/18/13 11/1/13 11/6/13		SHEET OF





USERNAME => s128843 DATE PLOTTED => 05-NOV-2014 TIME PLOTTED => 11:31



DIST	COUNTY	ROUTE	POST MILES TOTAL PROJECT	SHEET No	TOTAL SHEETS
08	SBd	58	R22.2/R31.1	717J	900
 REGISTERED CIVIL ENGINEER DATE 11/6/13					
5-5-14 PLANS APPROVAL DATE					
<i>The State of California or its officers or agents shall not be responsible for the accuracy or completeness of electronic copies of this plan sheet.</i>					

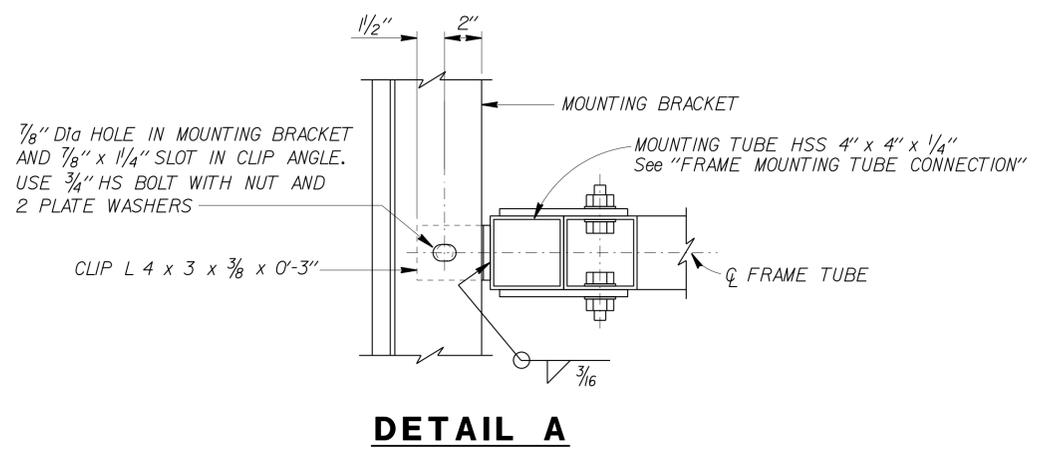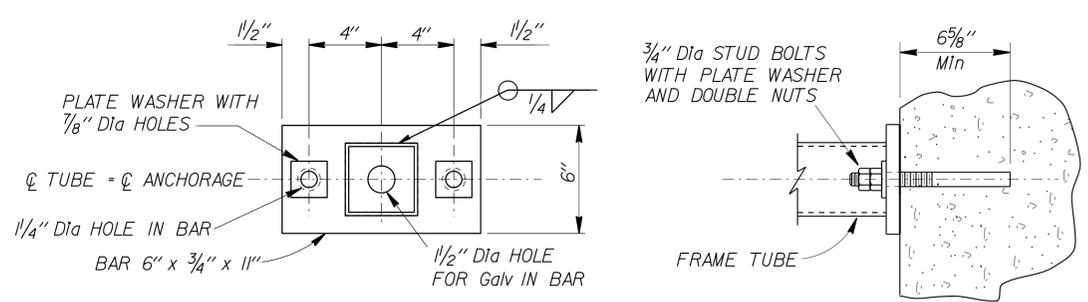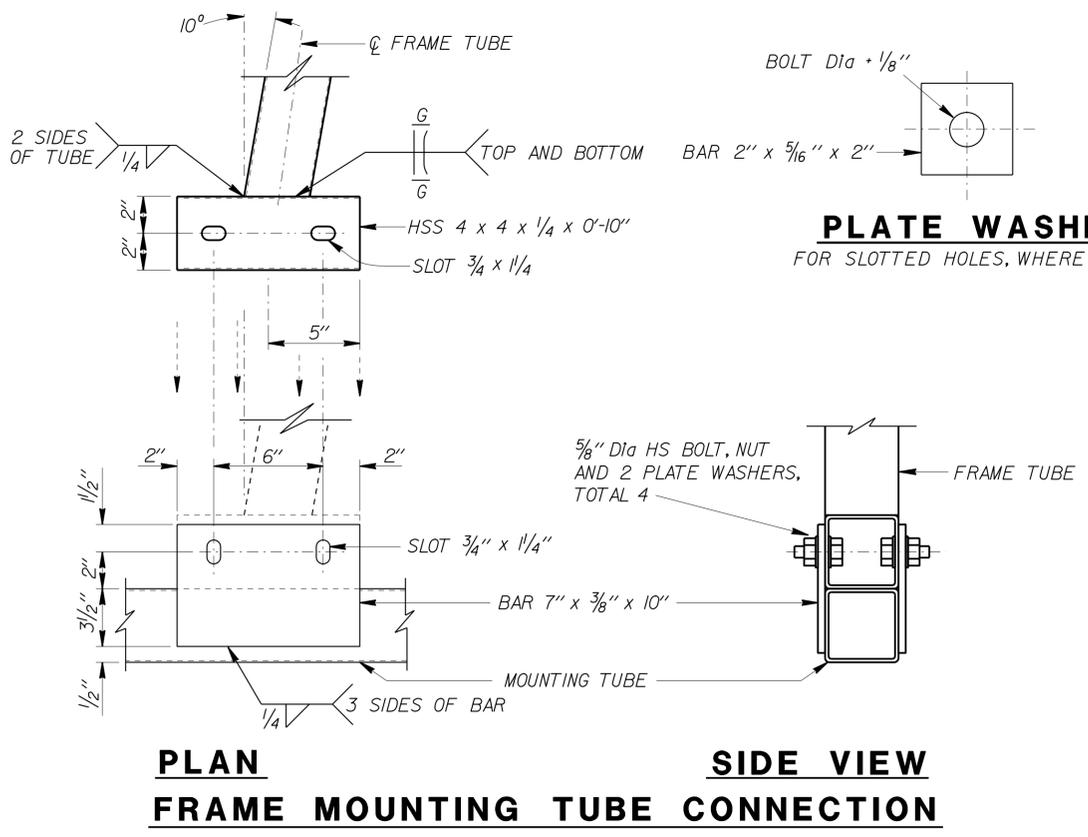

- NOTES:**
- Contractor to provide anchor bolt layout before anchor bolts are placed. Resin capsule bolt locations shall be laid out prior to pouring deck and barrier rail concrete to avoid interference with rebar, fence post, or conduit.
  - Where new resin capsule bolt anchorage coincides with fence post, adjust new mounting bracket to create a minimum distance of 6" measured from the centerline of nearest resin capsule bolt anchorage to the centerline of fence post or as approved by the Engineer.
  - Resin capsule anchorage is subject to approval of Engineer. Installation procedure shall comply with manufacturer's instructions.
  - Unless otherwise shown, all steel shall be galvanized after fabrication.
  - Resin capsule bolt anchors shall be installed in sound concrete free of cracks or delamination.

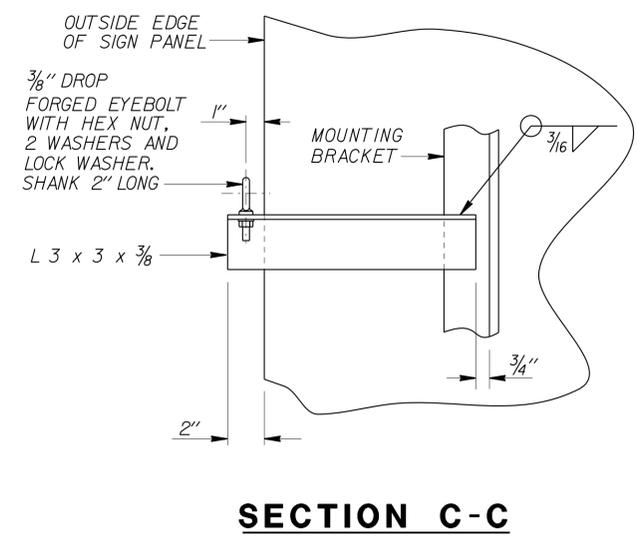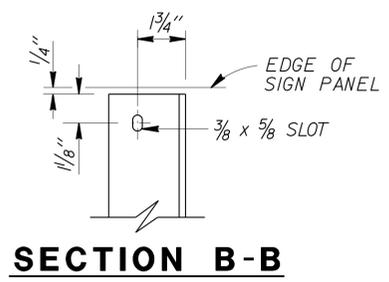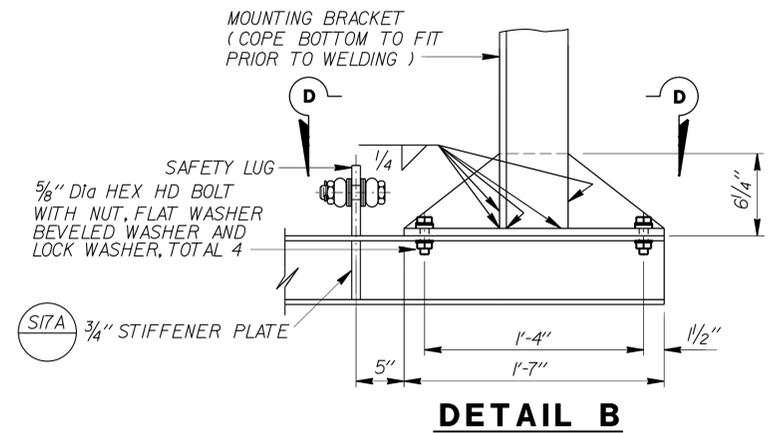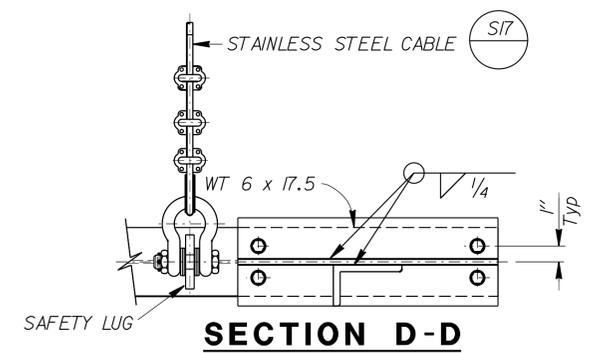

**6** ADDED PER ADDENDUM No. 6 DATED NOVEMBER 5, 2014

NOTE:  
 THE CONTRACTOR SHALL VERIFY ALL CONTROLLING FIELD DIMENSIONS BEFORE ORDERING OR FABRICATING ANY MATERIAL.

BRANCH CHIEF <b>JEFF WOODY</b>	DESIGN	BY <b>JUAN JAUREGUI</b>	CHECKED <b>ARLENA GUTIERREZ</b>	STATE OF CALIFORNIA DEPARTMENT OF TRANSPORTATION	DIVISION OF ENGINEERING SERVICES DESIGN AND TECHNICAL SERVICES SPECIAL DESIGNS BRANCH <b>A</b>	BRIDGE NO.	<b>HINKLEY ROAD OVERCROSSING</b> <b>BRIDGE MOUNTED SIGN - SKEWED</b> <b>TYPICAL DETAILS</b>	<b>SDS-10</b>
	DETAILS	BY <b>R. YEE</b>	CHECKED <b>JUAN JAUREGUI</b>			POST MILE		
QUANTITIES BY <b>JUAN JAUREGUI</b> CHECKED <b>ARLENA GUTIERREZ</b>		NO SCALE		UNIT: 3619 PROJECT NUMBER & PHASE: 080000010-1		CONTRACT NO.: 08-043511		SHEET OF

(ENGLISH) SPECIAL DESIGNS BRANCH BORDER SHEET (REV. 7-1-09)

ORIGINAL SCALE IN INCHES FOR REDUCED PLANS

DISREGARD PRINTS BEARING EARLIER REVISION DATES

REVISION DATES

FILE => /2013sd/08-043511/sds-10.dgn

USERNAME => s128843 DATE PLOTTED => 05-NOV-2014 TIME PLOTTED => 11:31