

INDEX OF PLANS

| SHEET No. | DESCRIPTION |
|-----------|---|
| 1 | TITLE AND LOCATION MAP |
| 2-3 | TYPICAL CROSS SECTIONS |
| 4 | LAYOUTS |
| 5-7 | CONSTRUCTION DETAILS |
| 8-9 | TEMPORARY WATER POLLUTION CONTROL PLANS AND DETAILS |
| 10-12 | DRAINAGE PLANS, PROFILES, QUANTITIES AND DETAILS |
| 13 | EDGE DRAIN PLANS |
| 14 | CONSTRUCTION AREA SIGNS |
| 15-18 | TRAFFIC HANDLING PLANS AND QUANTITIES |
| 19-20 | PAVEMENT DELINEATION PLANS AND QUANTITIES |
| 21-24 | SIGN PLANS AND QUANTITIES |
| 25 | SUMMARY OF QUANTITIES |
| 26-28 | LANDSCAPE PLANS |
| 29-39 | ELECTRICAL PLANS AND QUANTITIES |
| 40-78 | REVISED STANDARD PLANS |




STATE OF CALIFORNIA
DEPARTMENT OF TRANSPORTATION

**PROJECT PLANS FOR CONSTRUCTION ON
STATE HIGHWAY
IN ORANGE COUNTY
IN TUSTIN FROM TUSTIN RANCH ROAD OVERCROSSING
TO 0.3 MILE NORTH OF TUSTIN RANCH ROAD OVERCROSSING**

TO BE SUPPLEMENTED BY STANDARD PLANS DATED 2010

THE STANDARD PLANS LIST APPLICABLE TO THIS CONTRACT IS INCLUDED IN THE NOTICE TO BIDDERS AND SPECIAL PROVISIONS BOOK.

| Dist | COUNTY | ROUTE | POST MILES TOTAL PROJECT | SHEET No. | TOTAL SHEETS |
|------|--------|-------|--------------------------|-----------|--------------|
| 12 | Ora | 5 | 28.3/28.6 | 1 | 78 |

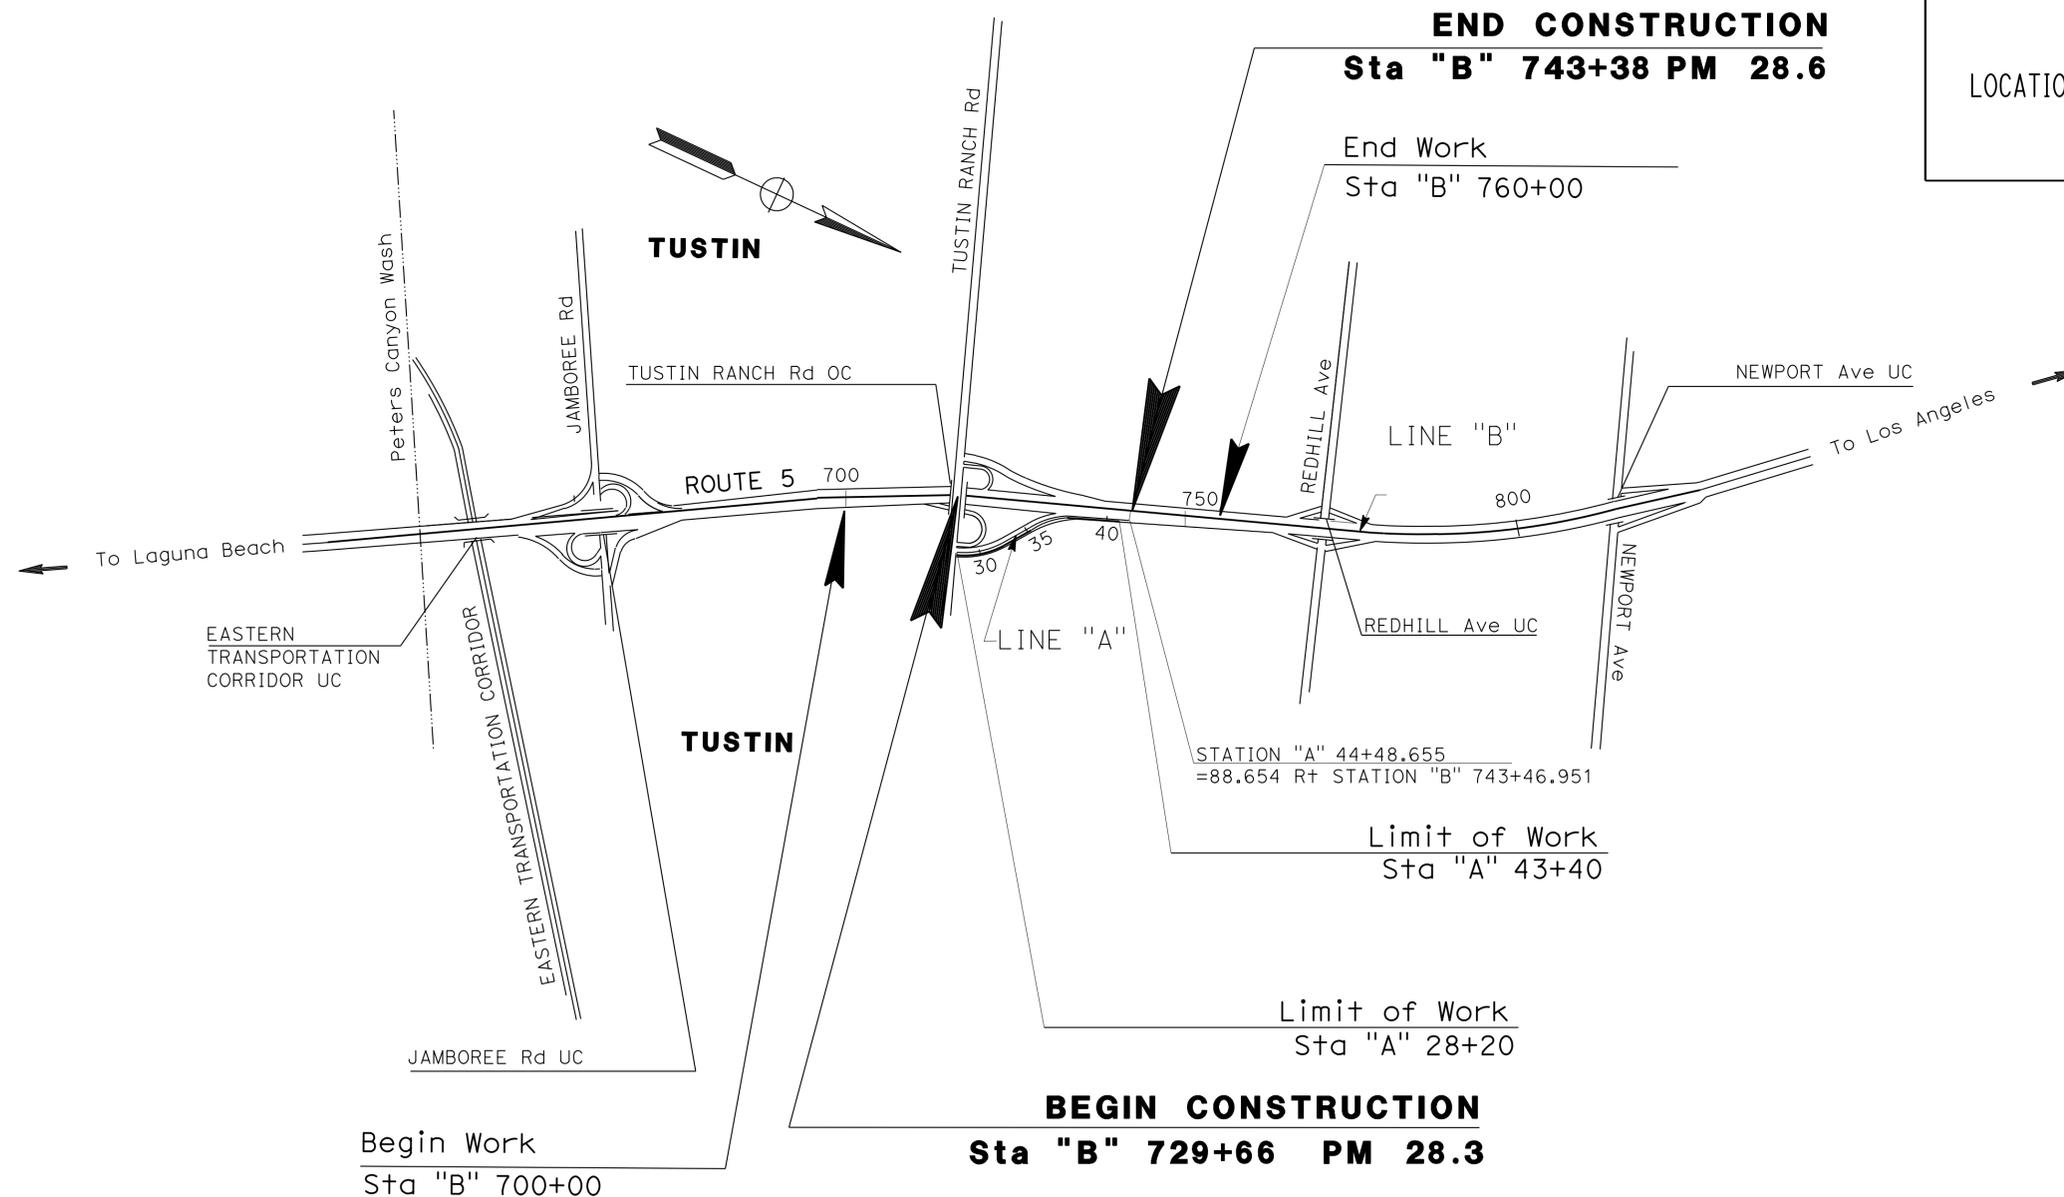

PROJECT MANAGER
BOB BAZARGAN

DESIGN MANAGER
KAMRAN MAZHAR

03-06-2015

PROJECT ENGINEER
REGISTERED CIVIL ENGINEER

DATE

MARCH 9, 2015

PLANS APPROVAL DATE

THE STATE OF CALIFORNIA OR ITS OFFICERS OR AGENTS SHALL NOT BE RESPONSIBLE FOR THE ACCURACY OR COMPLETENESS OF SCANNED COPIES OF THIS PLAN SHEET.

1 REPLACED PER ADDENDUM No. 1 DATED MAY 14, 2015

NO SCALE

| | | | | | |
|------|--------|-------|--------------------------|-----------|--------------|
| Dist | COUNTY | ROUTE | POST MILES TOTAL PROJECT | SHEET No. | TOTAL SHEETS |
| 12 | Ora | 5 | 28.3/28.6 | 8 | 78 |

03-06-15
 REGISTERED CIVIL ENGINEER DATE
 03-09-15
 PLANS APPROVAL DATE

REGISTERED PROFESSIONAL ENGINEER
 DUNG THANH PHAN
 No. C77219
 Exp. 06-30-15
 CIVIL
 STATE OF CALIFORNIA


THE STATE OF CALIFORNIA OR ITS OFFICERS OR AGENTS SHALL NOT BE RESPONSIBLE FOR THE ACCURACY OR COMPLETENESS OF SCANNED COPIES OF THIS PLAN SHEET.

NOTES:

1. LOCATION OF ALL TEMPORARY WATER POLLUTION CONTROL ARE APPROXIMATE, EXACT LOCATIONS TO BE DETERMINED BY THE ENGINEER.
2. FOR ACCURATE RIGHT OF WAY DATE, CONTACT RIGHT OF WAY ENGINEER AT THE DISTRICT OFFICE.

LEGEND:

-  TEMPORARY DRAINAGE INLET PROTECTION
-  TEMPORARY CONCRETE WASHOUT BIN
-  TEMPORARY CONSTRUCTION ENTRANCE
-  TEMPORARY FIBER ROLL

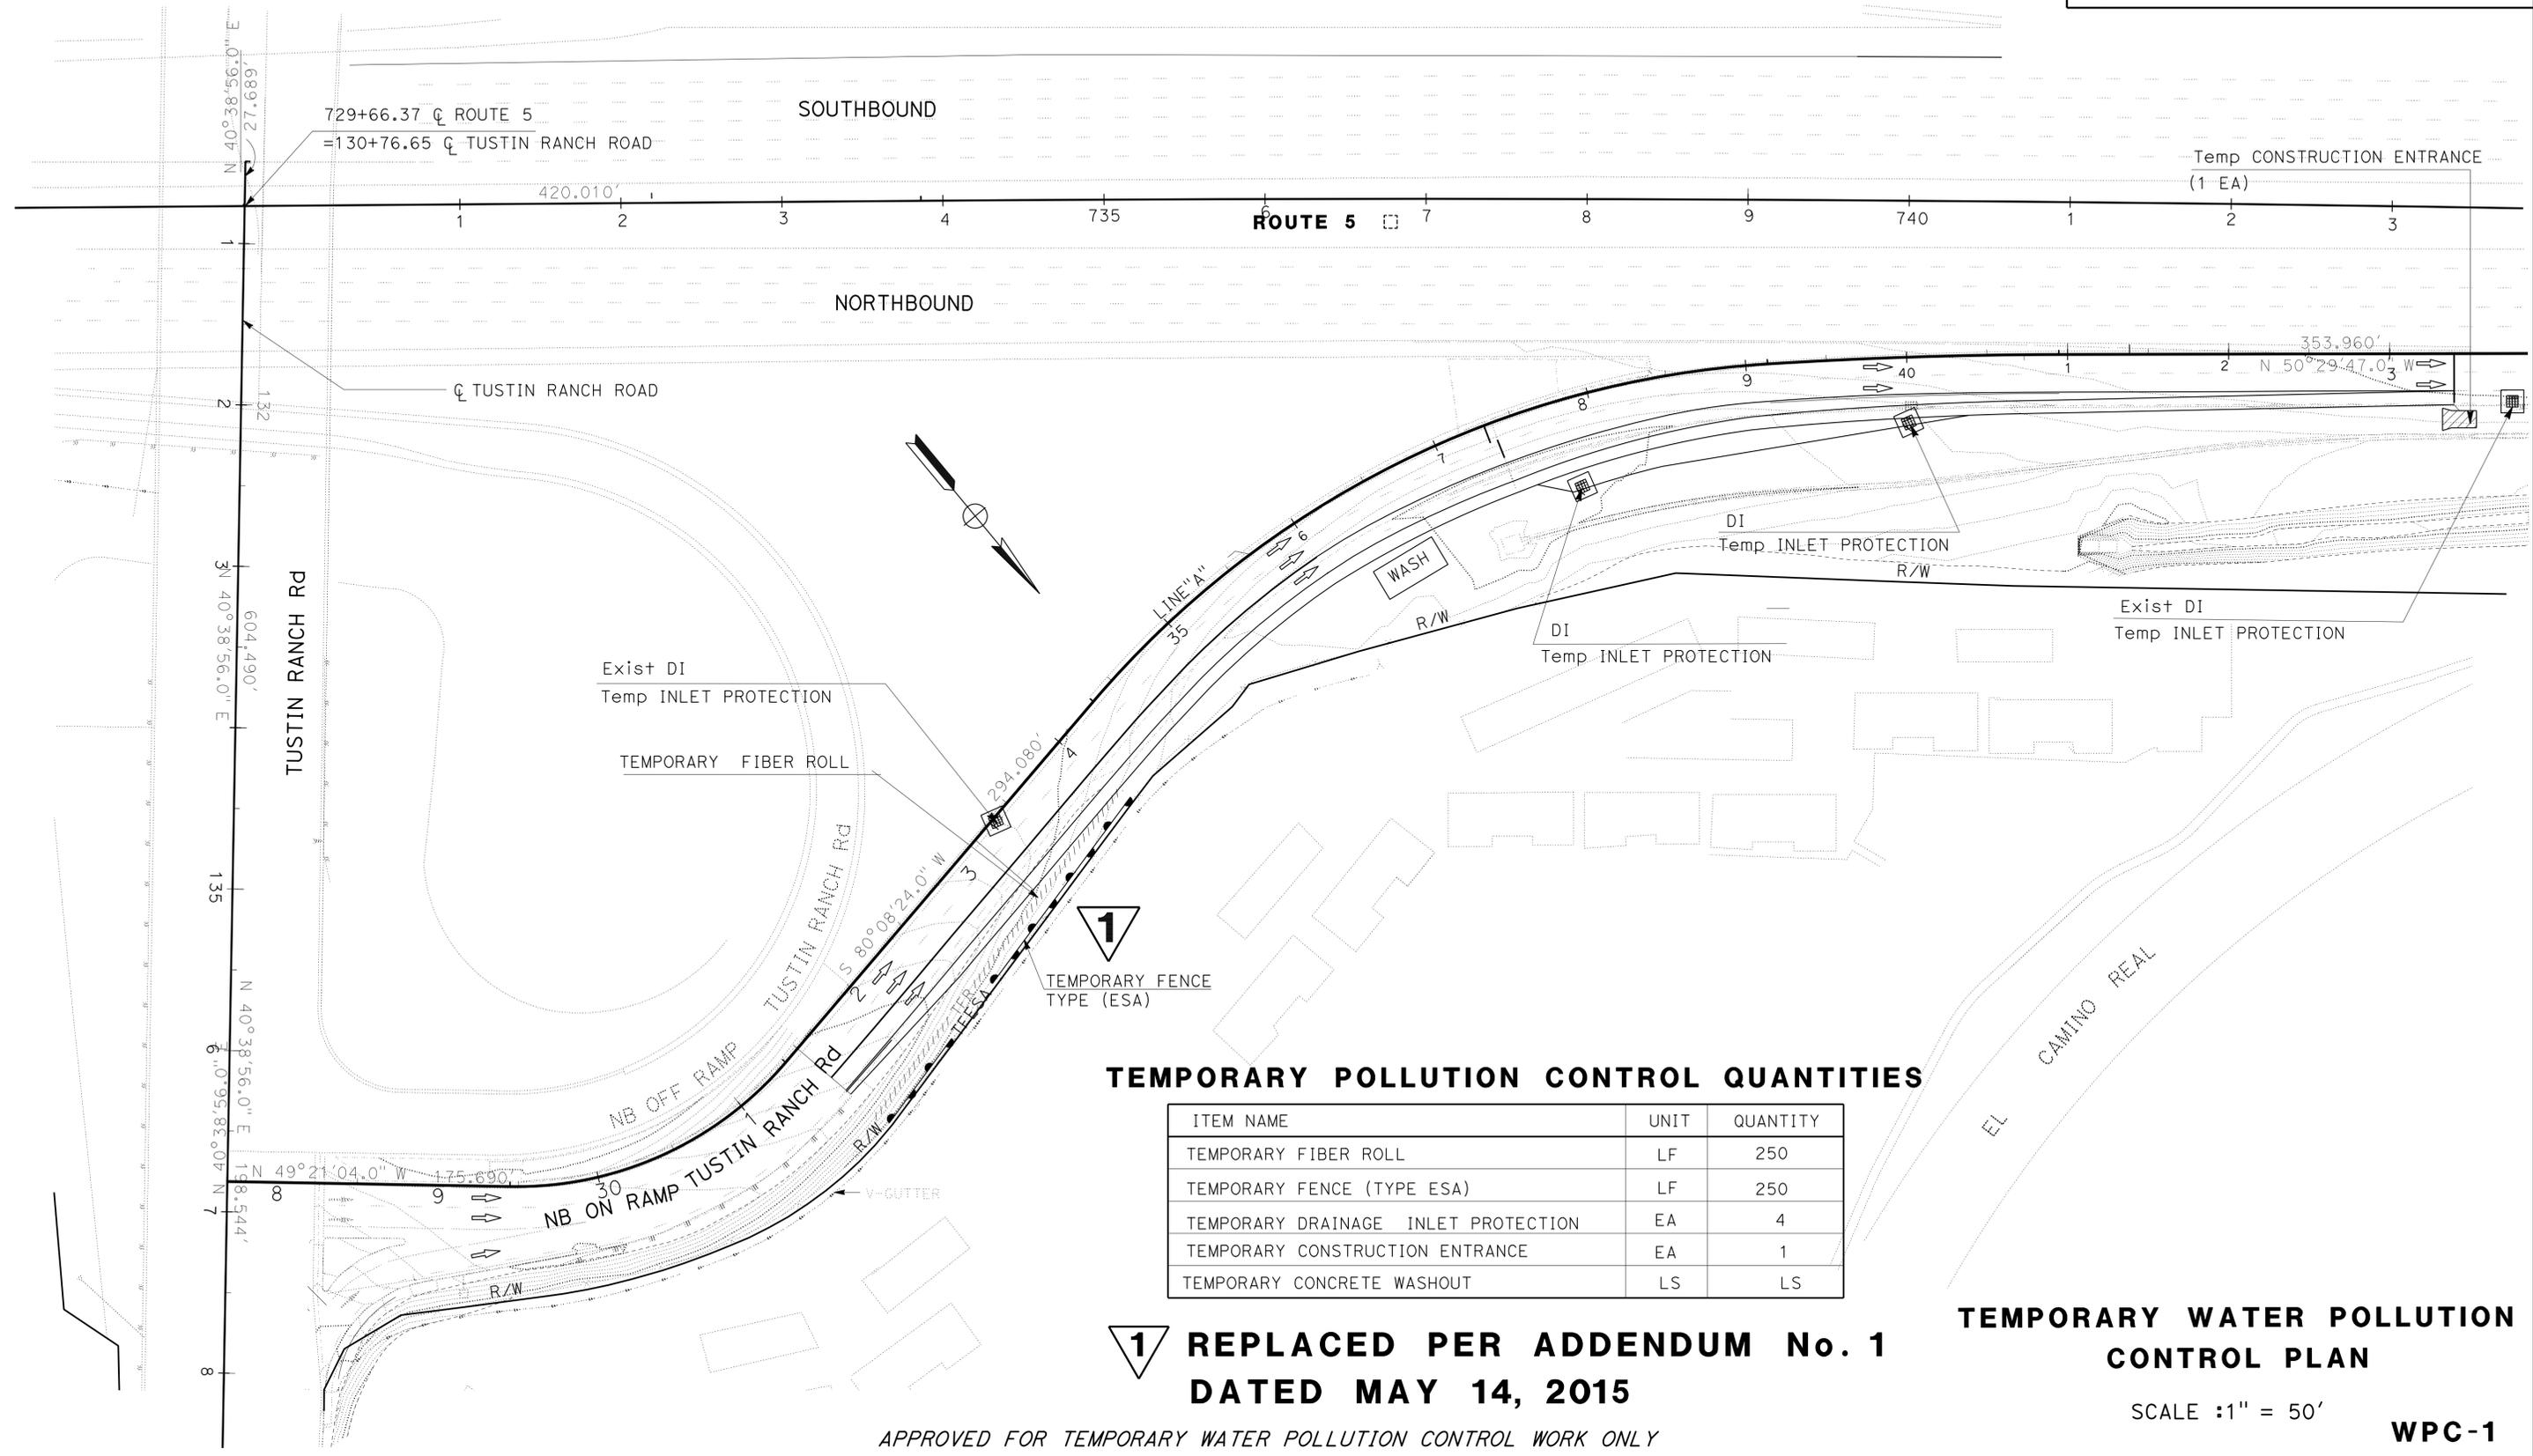

TEMPORARY POLLUTION CONTROL QUANTITIES

| ITEM NAME | UNIT | QUANTITY |
|-------------------------------------|------|----------|
| TEMPORARY FIBER ROLL | LF | 250 |
| TEMPORARY FENCE (TYPE ESA) | LF | 250 |
| TEMPORARY DRAINAGE INLET PROTECTION | EA | 4 |
| TEMPORARY CONSTRUCTION ENTRANCE | EA | 1 |
| TEMPORARY CONCRETE WASHOUT | LS | LS |

1 REPLACED PER ADDENDUM No. 1 DATED MAY 14, 2015

TEMPORARY WATER POLLUTION CONTROL PLAN

SCALE : 1" = 50'

WPC-1

APPROVED FOR TEMPORARY WATER POLLUTION CONTROL WORK ONLY

STATE OF CALIFORNIA - DEPARTMENT OF TRANSPORTATION
Caltrans DESIGN DIVISION
 FUNCTIONAL SUPERVISOR: KAMRAN MAZHAR
 CALCULATED/DESIGNED BY: DUNG PHAN
 CHECKED BY: ALMA OLGUIN
 REVISED BY: DUNG PHAN
 DATE REVISED: